


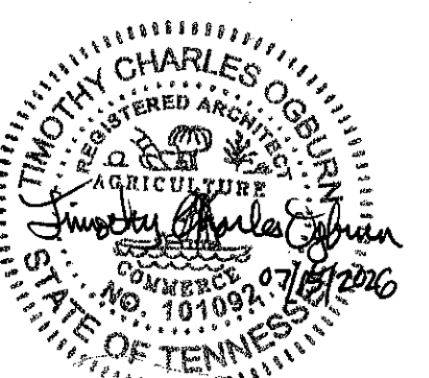

LIBRARY RESTROOM RENOVATIONS

JACKSON STATE COMMUNITY COLLEGE

42 JACKSON STATE DRIVE,
JACKSON , TN 38301
SBC No. 166/019-01-2025

63745
07.15.2026
CONSTRUCTION DOCUMENTS



Allen&Hoshall
engineers • architects • surveyors

Allen & Hoshall
1661 International Drive, Suite 100
Memphis, TN 38120
901 820 0820 fax 866 270 6330

Plotted on: 8/21/2026 1:55:33 PM

ABBREVIATIONS					
ABV	ABOVE	GA	GAGE, GAUGE	QT	QUARRY TILE
ACT	ACOUSTICAL CEILING TILE	GALV	GALVANIZED, GALVANIC	R	RADIUS , RISER
A/C	AIR CONDITIONING	GB	GYP SUM BOARD	RAD	RADIUS
ACC	ACCESSIBLE, ACCESSORIES	GC	GENERAL CONTRACTOR	RB	RUBBER BASE
ADD	ADDITIONAL	GEN	GENERAL	RC	REINFORCED CONCRETE
ADJ	ADJUSTABLE	GL	GLUE	RCP	REFLECTED CEILING PLAN
AFF	ABOVE FINISH FLOOR	GLU LAM	GLUE LAMINATED WOOD	RD	ROOF DRAIN, ROAD
AFG	ABOVE FINISH GRADE	GLZ CMU	GLAZED MASONRY UNIT	REC	RECESSED
ALT	ALTERNATE (IVE)	GOVT	GOVERNMENT	REF	REFER (ENCE) , REFRIGERATOR
AL, ALUM	ALUMINUM	GWB	GYP SUM WALL BOARD	REINF	REINFORCE (D), (ING)
APPROX	APPROXIMATE	GYP	GYP SUM	REQUIRED	
APT	APARTMENT	H	HIGH	RES	RESIDENTIAL, RESILIENT
ARCH	ARCHITECTURAL	HD HT	HEAD HEIGHT	RET	RETAINING
BD	BOARD	HDR	HEADER	REV	REVISION (S), REVISED
BITUM	BITUMINOUS	HDW	HARDWARE	RF	ROOF
BLDG	BUILDING	HDWD	HARDWOOD	RFG	ROOFING
BLKG	BLOCKING	HM	HOLLOW METAL	RH	ROOF HATCH, RIGHT HAND
BM	BEAM	HORIZ	HORIZONTAL	RL	ROOF LEADER
BO	BOTTOM OF	HT	HEIGHT	RM	ROOM
BOT	BOTTOM	HVAC	HEATING, VENTILATION, AND AIR CONDITIONING	RO	ROAD
B/N	BETWEEN	HWF	HARDWOOD FLOORING	ROW	RIGHT OF WAY
BR	BRICK	IBC	INTERNATIONAL BUILDING CODE	RST	RUBBER STAIR TREAD
BSMT	BASEMENT	ID	INSIDE DIAMETER	RT	RIGHT
BTU	BRITISH THERMAL UNIT	IN	INCHES	RTU	ROOF TOP UNIT
CAB	CABINET	INCL	INCLUDING(ED)	S&R	SHelf AND ROD
CFLG	COUNTERFLASH (ING)	INFO	INFORMATION	SB	SPLASH BLOCK
CFGI	CONTRACTOR FURNISHED ; OWNER INSTALLED	INSUL	INSULATION	SC	SEALED CONCRETE, SOLID CORE (DOOR)
CJ	CONTROL JOINT	INT	INTERIOR	SCR	SHOWER CURTAIN ROD
CLG	CEILING	INV	INVERT	SCHED	SCHEDULE
CL	CENTERLINE	JST	JOIST	SD	STORM DRAIN
CLO	CLOSET	JT	JOINT	SEC	SECURITY
CLR	CLEAR (ANCE)	KIT	KITCHEN	SECT	SECTION
CMU	CONCRETE MASONRY UNIT	LAM.	LAMINATE(D)	SF	SQUARE FOOT (FEET)
CNTR	COUNTER	LAV	LAVATORY	SHTG	SHEATHING
CO	CLEAN OUT	LB	ROUND	SHV	SHelf, SHELVING
COL	COLUMN	L	LONG, LENGTH	SIM	SIMILAR
CONC	CONCRETE	LF	LINEAR FEET	SL	SLOPE
CONSTR	CONSTRUCTION	LH	LEFT HAND	SOG	SLAB ON GRADE
CONT	CONTINUOUS	LNDSCP	LANDSCAPE	SP	SOUNDPROOF
CONTR	CONTRACT(OR)	LOC	LOCATION	SPEC	SPECIFICATION
COORD	COORDINATE	LTG	LIGHTING	SPKLR	SPRINKLER
CPT	CARPET(ED)	LVR	LUXURY	SQ	SQUARE
CR	CARD READER	LVT	LUXURY VINYL TILE	SQ IN	SQUARE INCH
CRS.	COURSES	MAS	MASONRY	SS	STANDING SEAM, SANITARY SEWER
CSMT	CASEMENT	MATL	MATERIAL	SSM	SOLID SURFACE MATERIAL
CT	CERAMIC TILE	MAX	MAXIMUM	SST	STAINLESS STEEL
CU FT	CUBIC FOOT (OR FEET)	MB	MARKER BOARD	ST	STAIR, STREET, STONE
D	DRYER	MC	MINIMUM CLEAR	STC	SOUND TRANSMISSION COEFFICIENT
DBL	DOUBLE	MECH	MECHANICAL	STD	STANDARD
DEMO	DEMOLISH; DEMOLITION	MEMB	MEMBRANE	STER	STERILIZER
DEPT	DEPARTMENT	MEZZ	MEZZANINE	STL	STEEL
DET	DETAIL	MFR	MANUFACTURER	STN	STAINED
DIA	DIAMETER	MIN	MINIMUM, MINUTE	STOR	STORAGE
DIAG	DIAGONAL	MIRR	MIRROR	STRUCT	STRUCTURE (AL)
DIM	DIMENSION	MISC	MISCELLANEOUS	SUSP	SUSPENDED
DISP	DISPENSER	MO	MASONRY OPENING	T	TREAD
DIST	DISTRIBUTION	MR	MOISTURE RESISTANT	T&G	TONGUE AND GROOVE
DN	DOWN	MRBL	MARBLE	TEL	TELEPHONE
DS	DOWNSPOUT	MTB	MARKER/TACK BOARD	TEMP	TEMPORARY, TEMPERED
DSPL	DISPOSAL	MTD	MOUNTED	TER	TERAZZO
DTLS.	DETAILS	MTG HT	MOUNTING HEIGHT	TFE	TOP OF FINISH FLOOR
DW	DISHWASHER	MTG	MOUNTING	THK	THICK (NESS)
DWR	DRAWER	MTL	METAL	THRES	THRESHOLD
DWGS	DRAWINGS	MULL	MULLION	THRU	THROUGH
EA	EACH	MULT	MULTIPLE	TILT	TOILET
EF	EXHAUST FAN	NA	NOT APPLICABLE	TN	TRUE NORTH
EJ	EXPANSION JOINT	NC	NON COMBUSTIBLE	TOB	TOP OF BEAM
ELEC	ELECTRIC (AL)	NIC	NOT IN CONTRACT	TOC	TOP OF CURB
ELEV	ELEVATOR, ELEVATION	NO	NUMBER	TOS	TOP OF SLAB
EP	EPOXY PAINT	NOM	NONMETAL	TOW	TOP OF WALL
EQ	EQUAL	NR	NOT RATED	TPD	TOILET PAPER DISPENSER
EQUIP	EQUIPMENT	NTS	NOT TO SCALE	TPTN	TOILET PARTITION
EOS	EMERGENCY OVERFLOW SCUPPER	O/	OVER	TRTD	TREATED
EST	ESTIMATE(D)	OA	OVERALL	TV	TELEVISION
EWS	EYE WASH STATION	OC	ON CENTER	TYP	TYPICAL
EX/EXIST	EXISTING	OCH	ON CENTER HORIZONTALLY	UL	UNDERWRITER'S LABORATORIES
EXP	EXPANSION	OCV	ON CENTER VERTICALLY	UNFIN	UNFINISH(ED)
EXT	EXTERIOR	OD	OUTSIDE DIAMETER	UNO	UNLESS NOTED OTHERWISE
EXTR	EXTRUDED	OF	OUTSIDE FACE	UR	URINAL
FD	FLOOR DRAIN	OFCI	OWNER FURNISHED CONTRACTOR INSTALLED	UTIL	UTILITY
FDN	FOUNDATION	OFOI	OWNER FURNISHED OWNER INSTALLED	VCT	VINYL COMPOSITE TILE
FE	FIRE EXTINGUISHER CABINET	OH	OVERHEAD	VEND	VENDING
FE	FIRE EXTINGUISHER ON WALL BRACKET	OPH	OPPOSITE HAND	VERT	VERTICAL
FFE	FINISH FLOOR ELEVATION	OPNG	OPENING	VIF	VERIFY IN FIELD
FHC	FIRE HOSE CABINET	OPP	OPPOSITE	VIN	VINYL
FIN	FINISH(ED)	ORD	OVERFLOW ROOF DRAIN	VR	VAPOR RETARDER
FIN FL/FF	FINISHED FLOOR	OVHD	OVERHEAD	VTR	VENT THROUGH ROOF
FL	FLASHING	OSB	ORIENTED STRAND BOARD	W	WASHER, WIDE
FLR	FLOOR	PAT	PATTERN	W/	WITH
FOC	FACE OF CONCRETE	PBD	PARTICLE BOARD	W/O	WITHOUT
FOF	FACE OF FINISH	PLYWD	PLYWOOD	WC	WALL COVERING, WATERCLOSET
FOM	FACE OF MASONRY	POLYETH	POLYETHYLENE	WCJ	WALL CONTROL JOINT
FOS	FACE OF STUDS	PCP	PORTLAND CEMENT PLASTER	WCO	WALL CLEAN OUT
FOW	FACE OF WALL	PED	PEDISTAL	WD	WOOD
FP	FIRE PROOF (ING)	PERF	PERFORATED	W/D	WASHER/DRYER
FR	FIRE RATED	PERIM	PERIMETER	WG	WIRED GLASS
FRMG	FRAMING	PERM	PERMINENT	WIND	WINDOW
FRP	FIBERGLASS REINFORCED PLASTIC	PERP	PERPENDICULAR	WO	WINDOW OPENING
FT	FOOT, FEET	PH	PHASE	WOM	WALK OFF MAT
FTG	FOOTING	PL	PROPERTY LINE	WP	WATER PROOFING
FURN	FURNITURE	PLAM	PLASTIC LAMINATE	WR	WATER RESISTANT
FUT	FUTURE	PLAS	PLASTER	VFCI	VENDOR FURNISHED, CONTRACTOR INSTALLED
FWC	FABRIC WALL COVERING	PLBG	PLUMBING	VFOI	VENDOR FURNISHED, OWNER INSTALLED
		PLWD	PLYWOOD		
		PNL	PANEL		
		PNT	PAINT(ED)		
		POR	PORCELAIN		
		PR	PAIR		
		PRCST	PRECAST		
		PREFAB	PREFABRICATED		
		PRELIM	PRELIMINARY		
		PRKG	PARKING		
		PROJ	PROJECT		
		PROP	PROPERTY		
		PT	POST TENSION, PRESSURE TREATED		
		PTN	PARTITION		
		PVG	PAVING		
		PWR	POWER		

SYMBOL LEGEND	
	NORTH ARROW
	ENLARGED PLAN OR PLAN DETAIL
	ROOM NAME & ROOM NUMBER
	ELEVATION
	SECTION
	COLUMN GRID
	DOOR NUMBER
	WINDOW / STOREFRONT TYPE
	WALL TYPE
	CENTERLINE
	SPOT ELEVATION
	FLOOR DRAIN
	LEVEL NAME
	ELEVATION
	NEW KEYNOTE TAG
	DEMO KEYNOTE TAG
	REVISION TAG
	SPECIALTY EQUIPMENT TAG
	TOILET ACCESSORIES TAG

INDEX OF DRAWINGS					
SHEET NUMBER	SHEET NAME	SHEET ISSUE DATE	NUMB ER	REVISION	
				DESCIPTION	DATE
	COVER SHEET	07.15.2026			
ARCHITECTURAL					
A0.1	ABBREVIATIONS, SYMBOLS, SHEET INDEX, AND CODE DATA	07.15.2026			
A0.2	OVERALL FLOOR PLAN	07.15.2026			
A1.1	NEW WORK FLOOR PLAN	07.15.2026			
A3.1	REFLECTED CEILING PLAN	07.15.2026			
A11.1	INTERIOR ELEVATIONS AND DETAILS	07.15.2026			
A11.2	INTERIOR ELEVATIONS AND DETAILS	07.15.2026			
A12.1	FINISH PLAN, FINISH SCHEDULE, AND FINISH LEGEND	07.15.2026			
AD1.0	DEMOLITION PLAN	07.15.2026			
PLUMBING					
P0.1	LEGEND, NOTES, AND SCHEDULES - PLUMBING	07.15.2026			
P1.1	ENLARGED PLAN VIEWS - PLUMBING	07.15.2026			
ELECTRICAL					
E0.1	LEGEND & NOTES	07.15.2026			
E1.1	DEMOLITION & NEW WORK - ELECTRICAL	07.15.2026			

PROJECT CODE DATA

Project Client: JACKSON STATE COMMUNITY COLLEGE

Project Location: 42 JACKSON STATE DRIVE, JACKSON TN 38301

Project Description: LIBRARY RESTROOM RENOVATION AT THE LIBRARY BUILDING

Scope of Work: This project consists of a approximately 650 SF interior finish renovation to the existing restrooms in this facility. The existing finishes will be demolished. The substrates will be prepared to receive new finishes. The lighting in the spaces will be upgraded as well as new fixtures installed. In the Janitor's Closet, the floor slab will be partially demolished and a sanitary pipe will be repaired. New fixtures, finishes and accessories will be installed in the renovated spaces.

Applicable Codes (State of Tennessee):

International Building Code IBC 2021
International Existing Building Code IEBIC 2021 - Alteration Level 1 (Chapter 7)
International Plumbing Code IPC 2021
International Mechanical Code IMC 2021
National Electrical Code NEC 2017
International Fire Code IFC 2021

International Energy Conservation Code - 2021

Zone Map C301. This project is located in Zone 3A

Chapter 3 - Use and Occupancy Classification

This building is a library and is classified as *Assembly*, Group *A-3* occupancy per 303.4.

The original building was constructed in 1966. The addition was built in 1970.

The building is Unsprinklered.

The square footage is 18,495 SF at the First Floor.

The square footage is 8,620 SF at the Second Floor.

The overall total building square footage including both floors is 27,115 SF.

The building is a Type II B per Table 601.

The building structure is composed of concrete columns, beams and floor slabs with a masonry exterior. The interior walls are composed of masonry CMU with steel studs and gypsum board.

All restrooms are located on the first floor.

This project shall meet the requirements for a **Seismic Design Category D**.

Chapter 8 - Interior Finishes

Per Table 803.13 - The Fire classification of materials required for A-3 Assembly, Unsprinklered Building is Class A minimum for exit passageways, ramps and stairways. Class A is required for corridors and exit passageways. A minimum of Class C fire rated finishes are required for Rooms and enclosed spaces. The proposed interior finishes for this project are Class A minimum therefore; the documents comply.

Responding Fire Department

Jackson, TN Fire Department
2432 Technology Center Drive
Jackson, TN 38301
731-424-5577

City of Jackson, Code Compliance Department

119 East Main Street
Suite 205
Jackson, TN 38301
731-425-8262




Allen&Hoshall
engineers • architects • surveyors

Allen & Hoshall
1661 International Drive, Suite 100
Memphis, TN 38120
901 820 0820 fax 966 270 6330

© ALLEN & HOSHALL

This document is proprietary and shall not be reproduced or used by others without prior written consent. These drawings are intended to be plotted in color. Contractor assumes all risk in utilizing these drawings in any other manner.

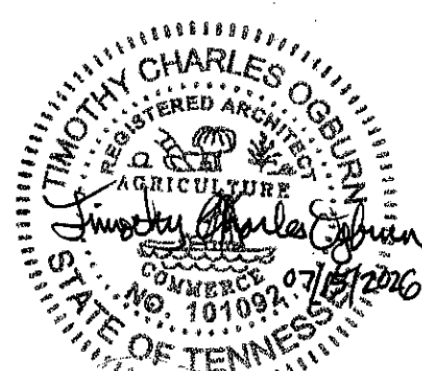

LIBRARY RESTROOM RENOVATION

SBC PROJECT NUMBER 166/019-01-2025

42 JACKSON STATE DRIVE,
JACKSON, TN 38301

JACKSON STATE COMMUNITY COLLEGE

No.	Revision Description	Date
-----	----------------------	------

ABBREVIATIONS, SYMBOLS, SHEET INDEX, AND CODE DATA

JOB NO: 63745

DRAWN: ASB

DATE: 07.15.2026

CONSTRUCTION DOCUMENTS




A0.1



Allen&Hoshall
engineers • architects • surveyors

Allen & Hoshall
1661 International Drive, Suite 100
Memphis, TN 38120
901 820 0820 fax 866 270 6330

© ALLEN & HOSHALL
This document is proprietary and shall not be reproduced or used by others without prior written consent.
These drawings are intended to be plotted in color. Contractor assumes all risk in utilizing these drawings in any other manner.

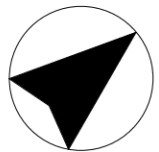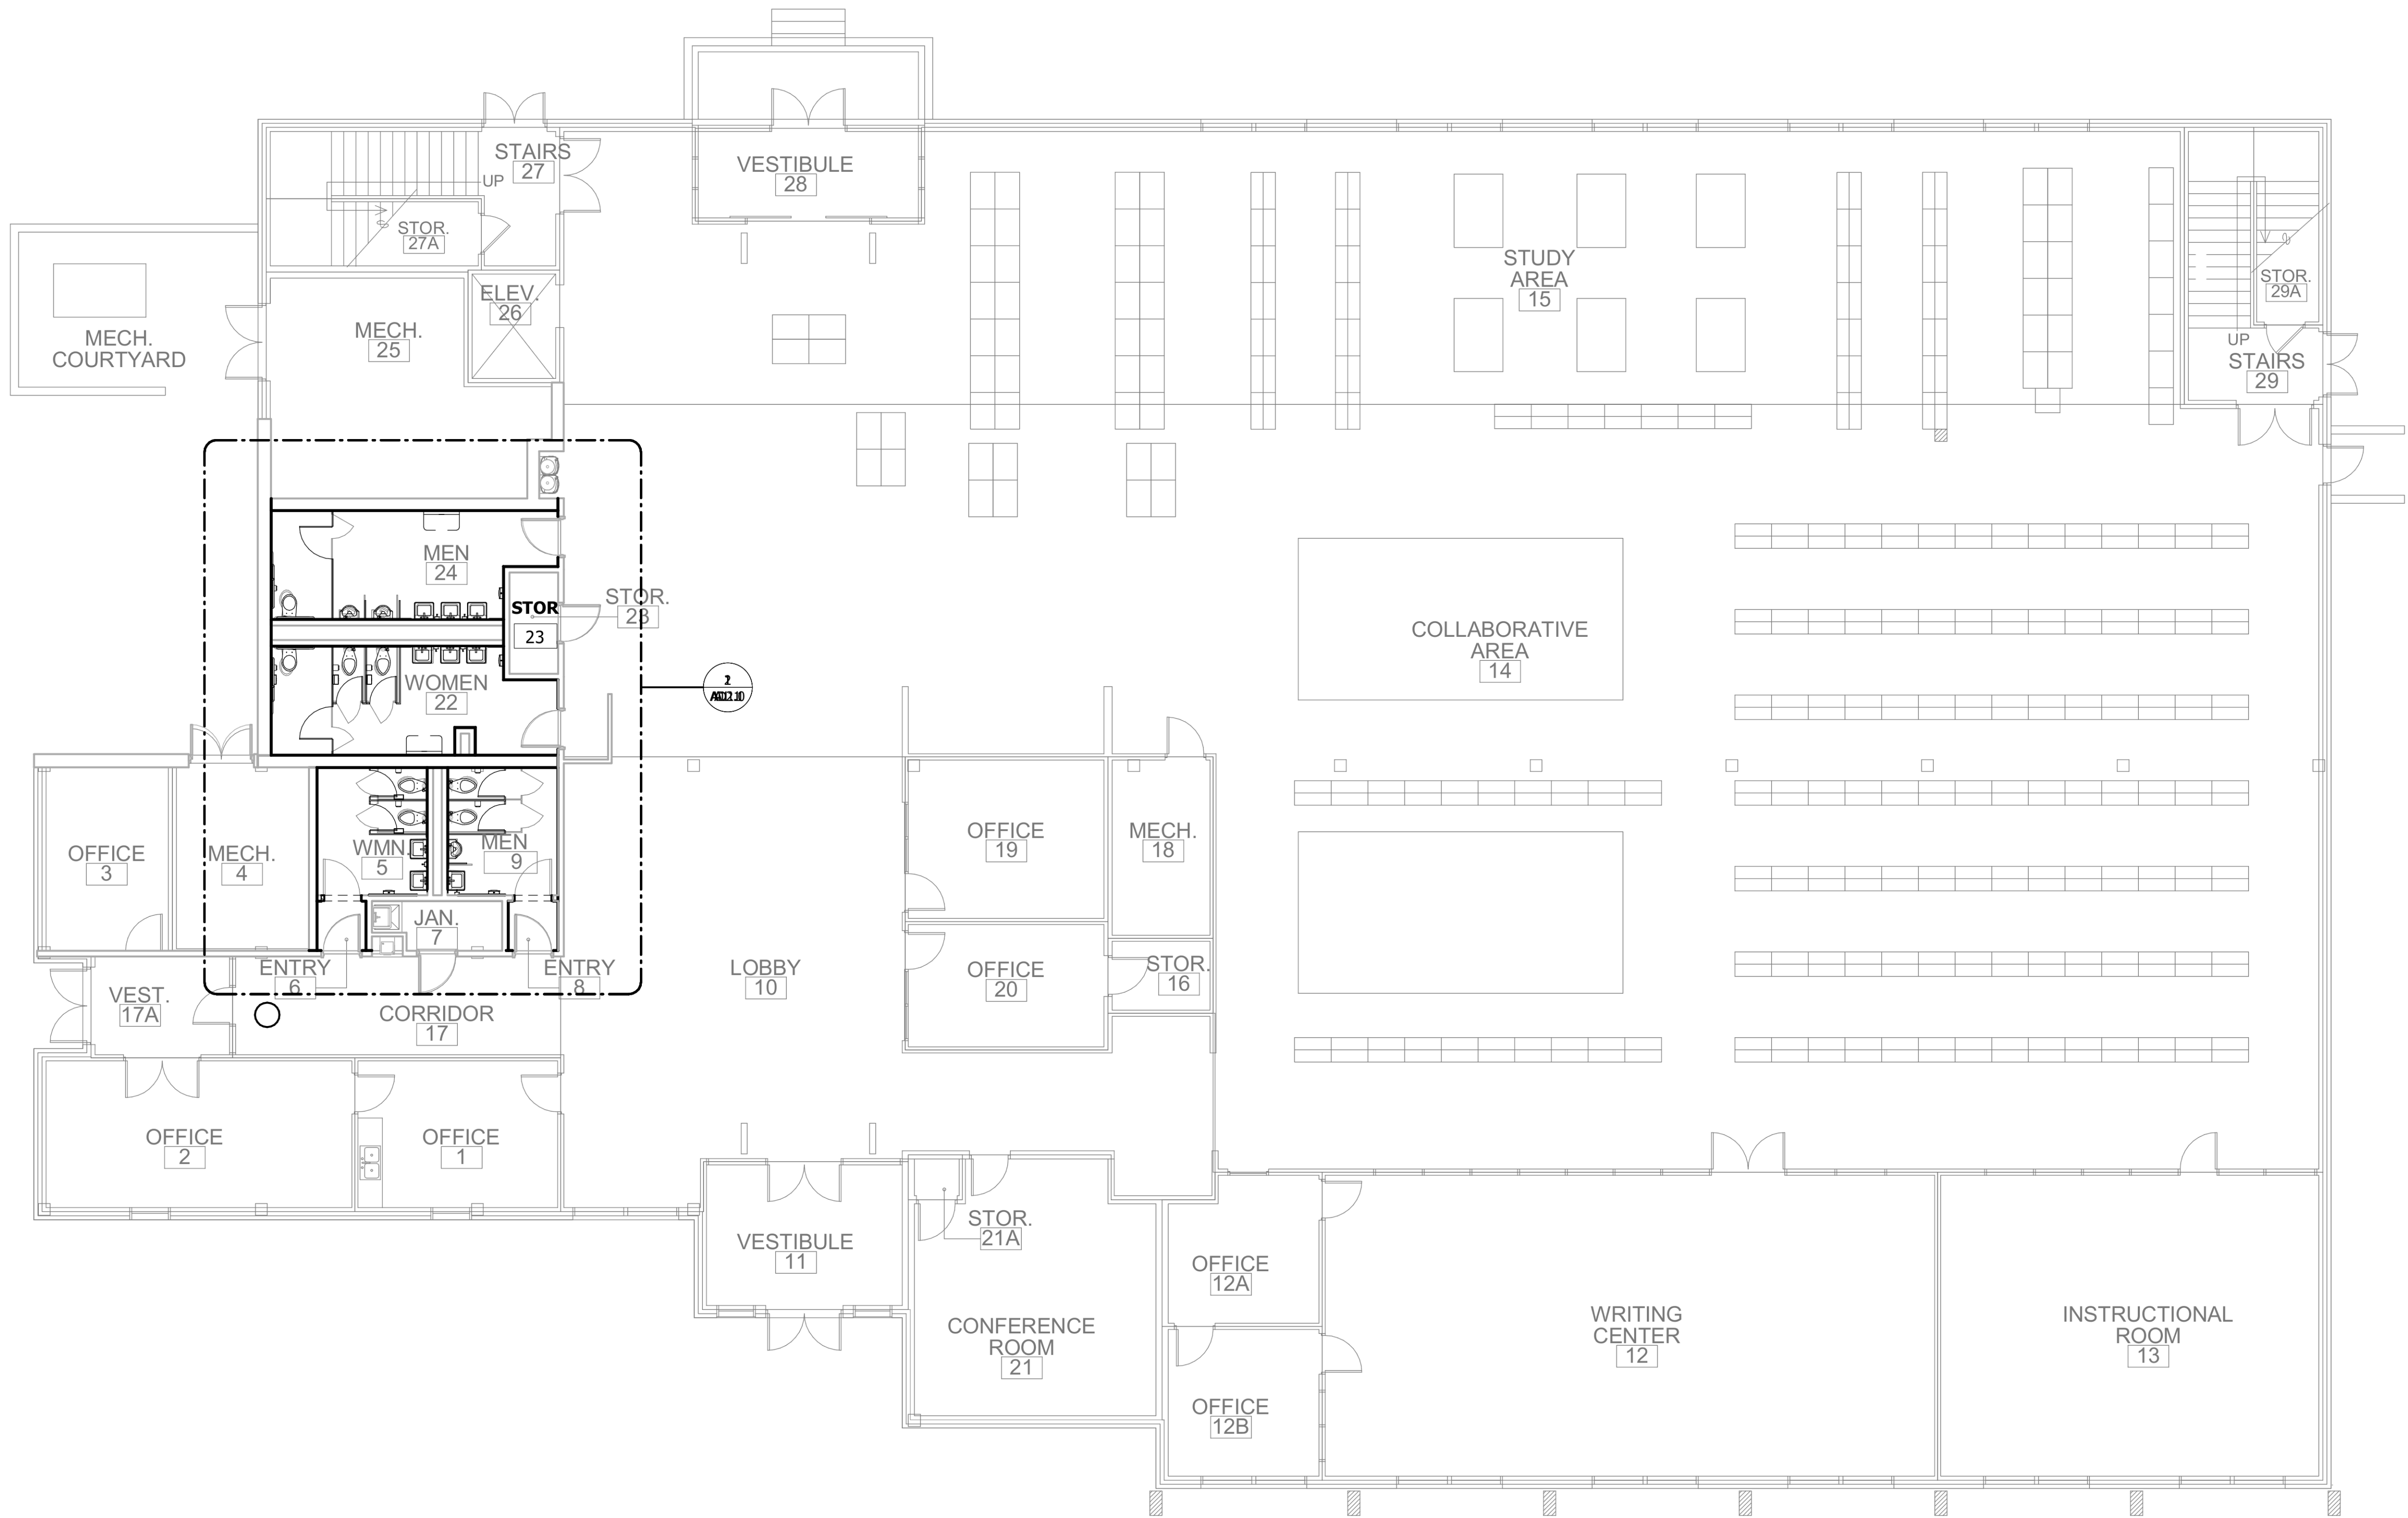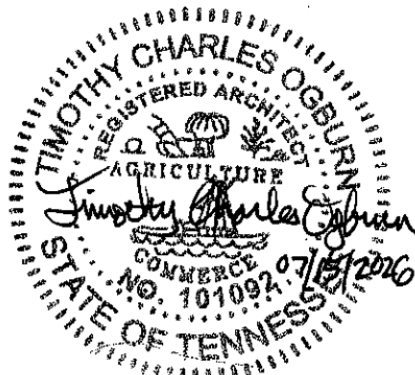

1 FIRST FLOOR - FLOOR PLAN
1/8" = 1'-0"

LIBRARY RESTROOM RENOVATION

SBC PROJECT NUMBER 166/019-01-2025

42 JACKSON STATE DRIVE,
JACKSON, TN 38301

JACKSON STATE COMMUNITY COLLEGE

No.	Revision Description	Date

OVERALL FLOOR PLAN

JOB NO: 63745 DRAWN: ASB
DATE: 07.15.2026 CONSTRUCTION DOCUMENTS

A0.2



© ALLEN & HOSHALL
This document is proprietary and shall not be reproduced or used by others without prior written consent. These drawings are intended to be plotted in color. Contractor assumes all risk in utilizing these drawings in any other manner.



42 JACKSON STATE DRIVE,
JACKSON, TN 38301

NEW WORK FLOOR PLAN

JOB NO: 63745 DRAWN: ASB
DATE: 07.15.2026 CONSTRUCTION DOCUMENTS


A1.1

FIRE RATING LEGEND			
COLOR		WALL TYPE	FIRE RESISTANCE RATING
EXISTING	NEW		
		FIRE PARTITION	 30 MIN.
		FIRE BARRIER	 1 HOUR
		FIRE WALL	 2 HOUR
			 3 HOUR
			 4 HOUR
FIRE RATING CAN BE ANY COMBINATION OF THE ABOVE COLORS AND PATTERN. FIRE AND SMOKE RATINGS SHOWN ON ARCHITECTURAL PLANS ARE FOR REFERENCE PURPOSES ONLY. REFER TO LIFE SAFETY PLANS FOR COORDINATION AND CONSTRUCTABILITY PURPOSES. THIS IS A STANDARD LEGEND, WALL TYPES MAY BE SHOWN BUT NOT UTILIZED IN THE PROJECT.			

SMOKE RATING LEGEND		
EXISTING	NEW	WALL TYPE
		SMOKE PARTITION
		SMOKE BARRIER




Plotted on: 8/21/2026 1:55:34 PM

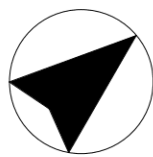

1

FIRST FLOOR - REFLECTED CEILING PLAN

1/4" = 1'-0"

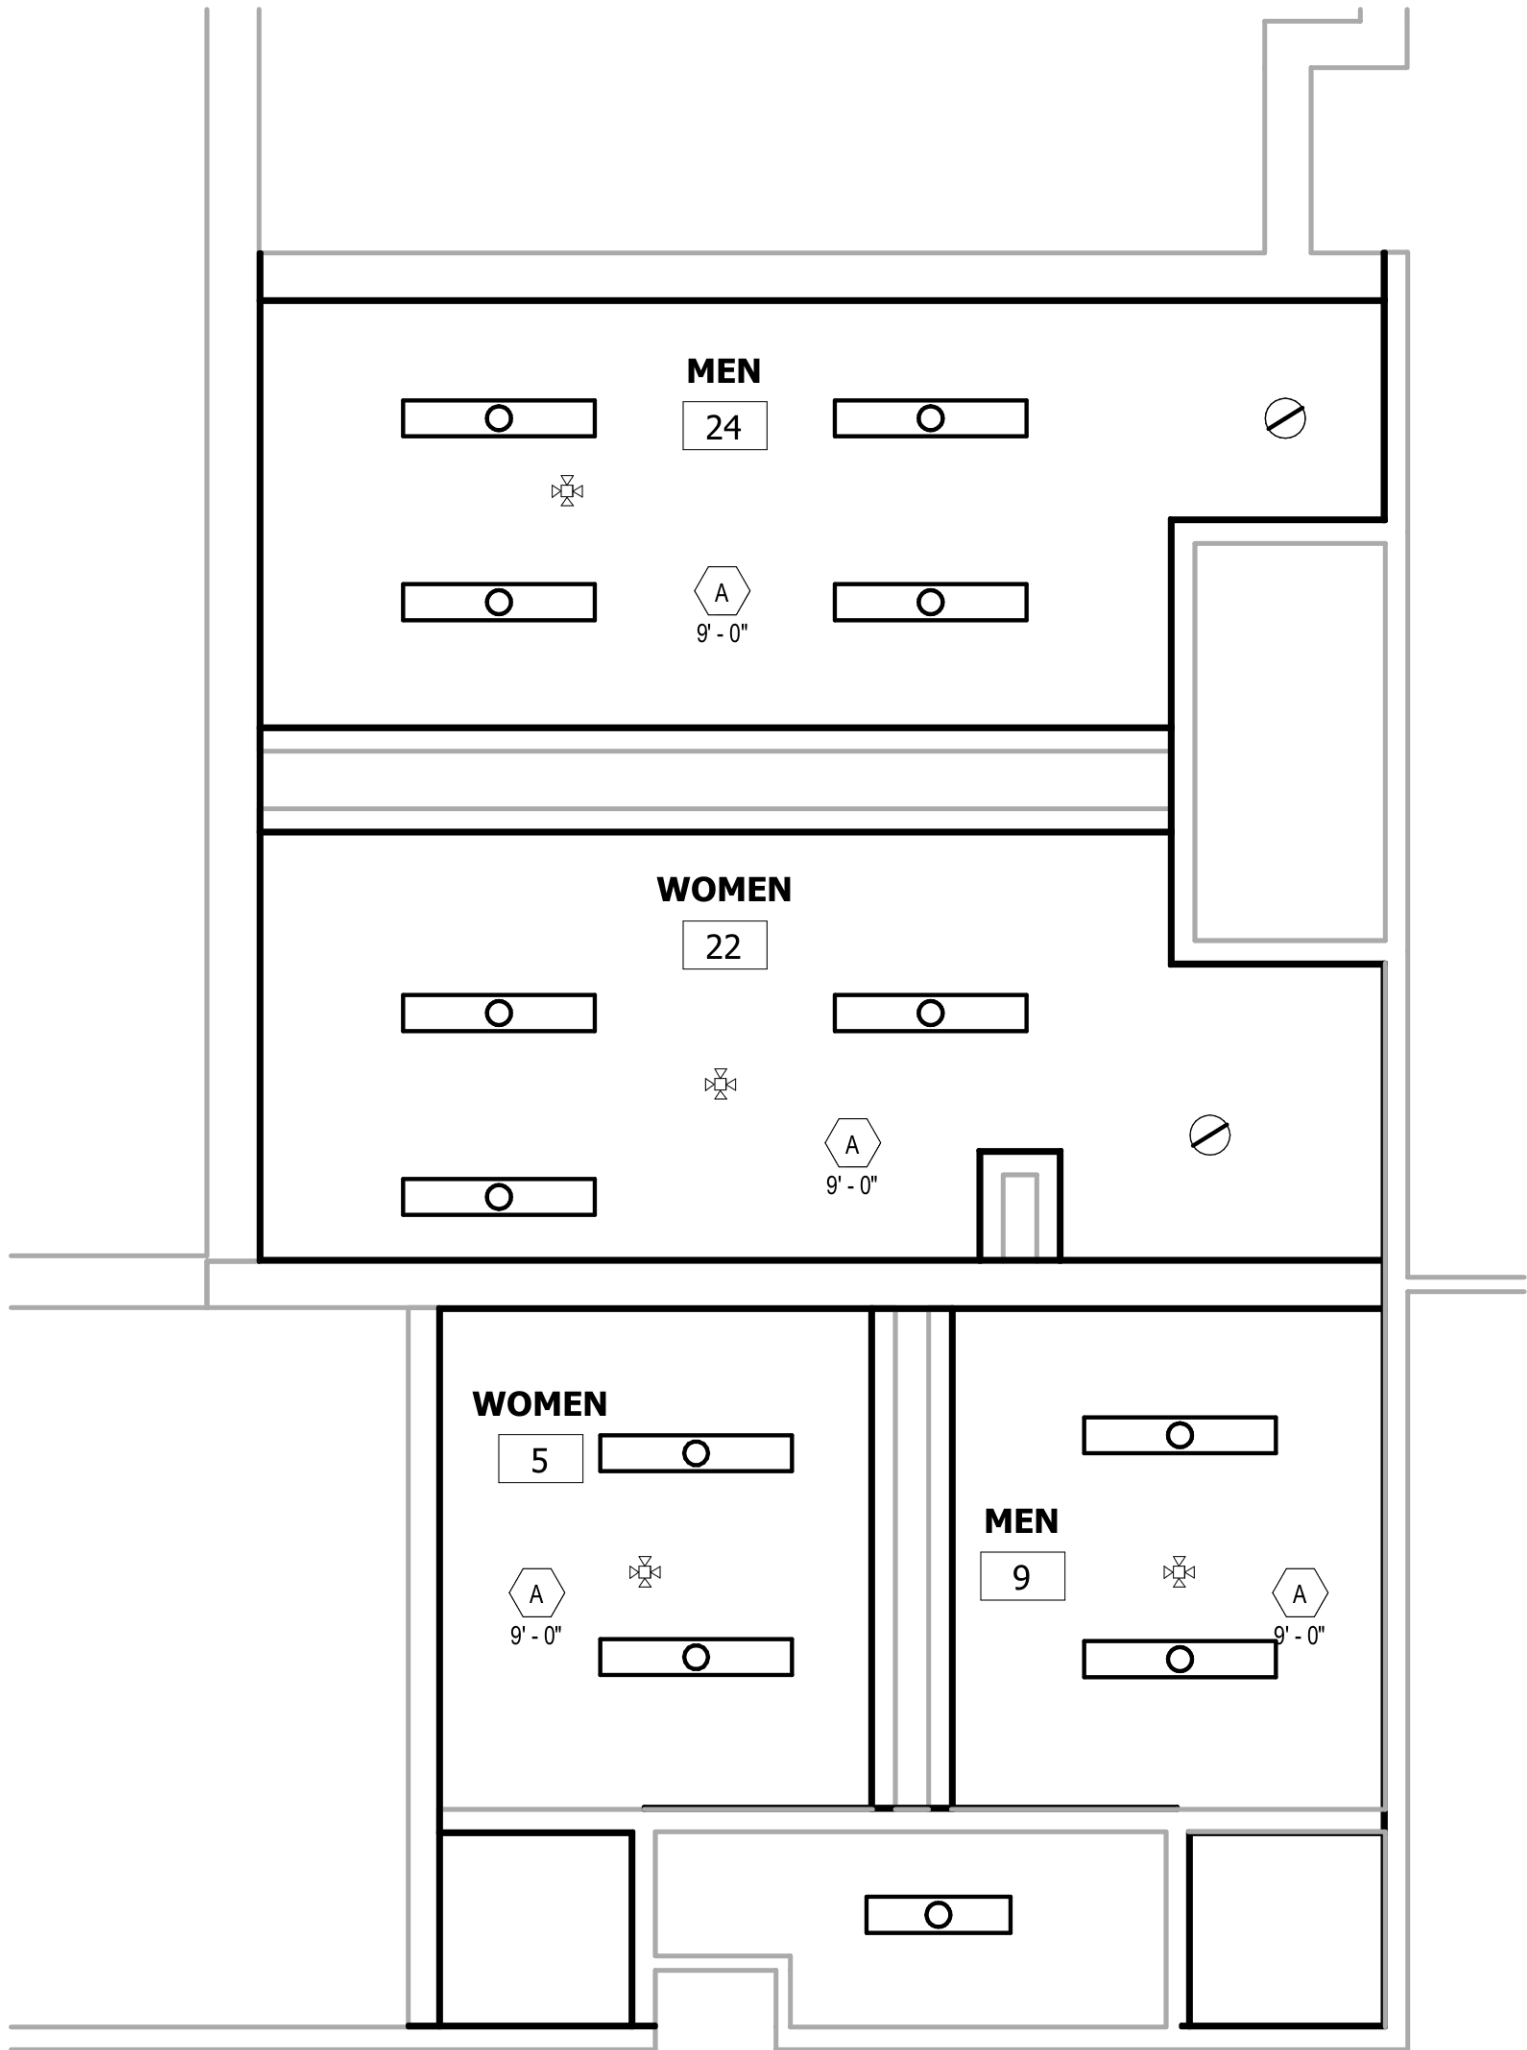

REFLECTED CEILING PLAN LEGEND

CEILING MATERIAL
CEILING HEIGHT

EXISTING GYP. BOARD CEILING TO REMAIN. PAINT CEILINGS.

CEILING MOUNTED LIGHT FIXTURE - SEE ELEC.

SQUARE 4' LIGHT FIXTURE - SEE ELEC.

FIRE STROBE - SEE ELEC.

RCP NOTES

1. WHERE MODIFICATIONS ARE REQUIRED TO ACCOMMODATE THE REPLACEMENT OF LIGHTING FIXTURES OR NEW DEVICES, THE REPAIR OF THE CEILING SHALL INCLUDE MOISTURE-RESISTANT GYPSUM BOARD.


2. REFER TO ELECTRICAL PLANS FOR LIGHTING FIXTURE LOCATIONS.



Allen&Hoshall
engineers • architects • surveyors

Allen & Hoshall
1661 International Drive, Suite 100
Memphis, TN 38120
901 820 0820 fax 866 270 6330

© ALLEN & HOSHALL
This document is proprietary and shall not be reproduced or used by others without prior written consent.
These drawings are intended to be plotted in color. Contractor assumes all risk in utilizing these drawings in any other manner.

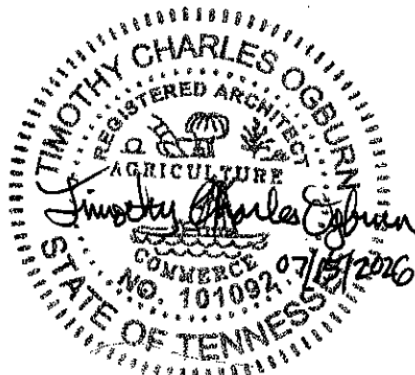

LIBRARY RESTROOM RENOVATION

SBC PROJECT NUMBER 166/019-01-2025

42 JACKSON STATE DRIVE,
JACKSON, TN 38301


JACKSON STATE COMMUNITY COLLEGE

No.	Revision Description	Date


REFLECTED CEILING PLAN

JOB NO: 63745 DRAWN: ASB
DATE: 07.15.2026 CONSTRUCTION DOCUMENTS


A3.1

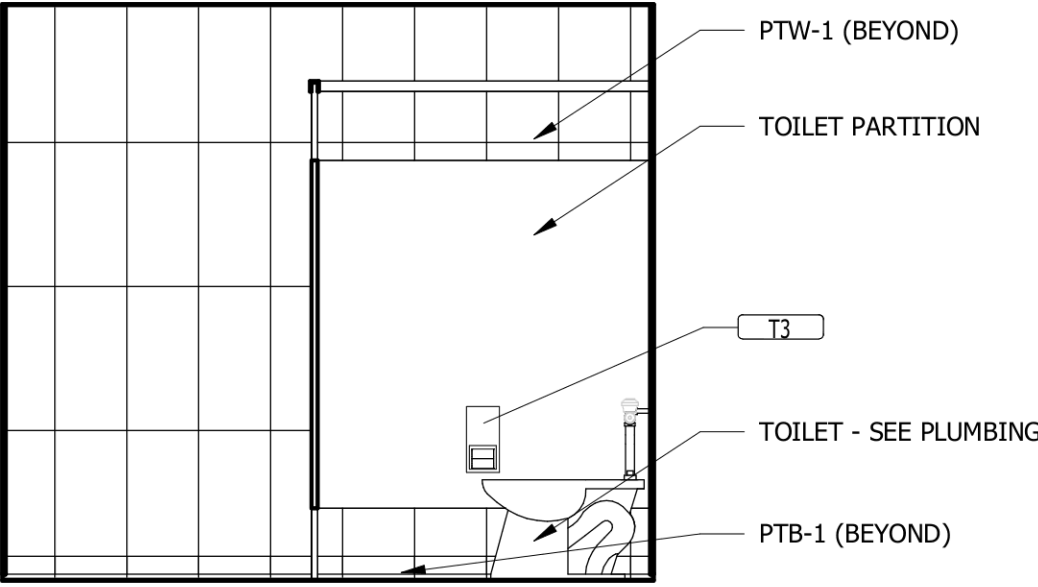


1 INT. ELEV. 1 @ WOMEN 5
3/8" = 1'-0"

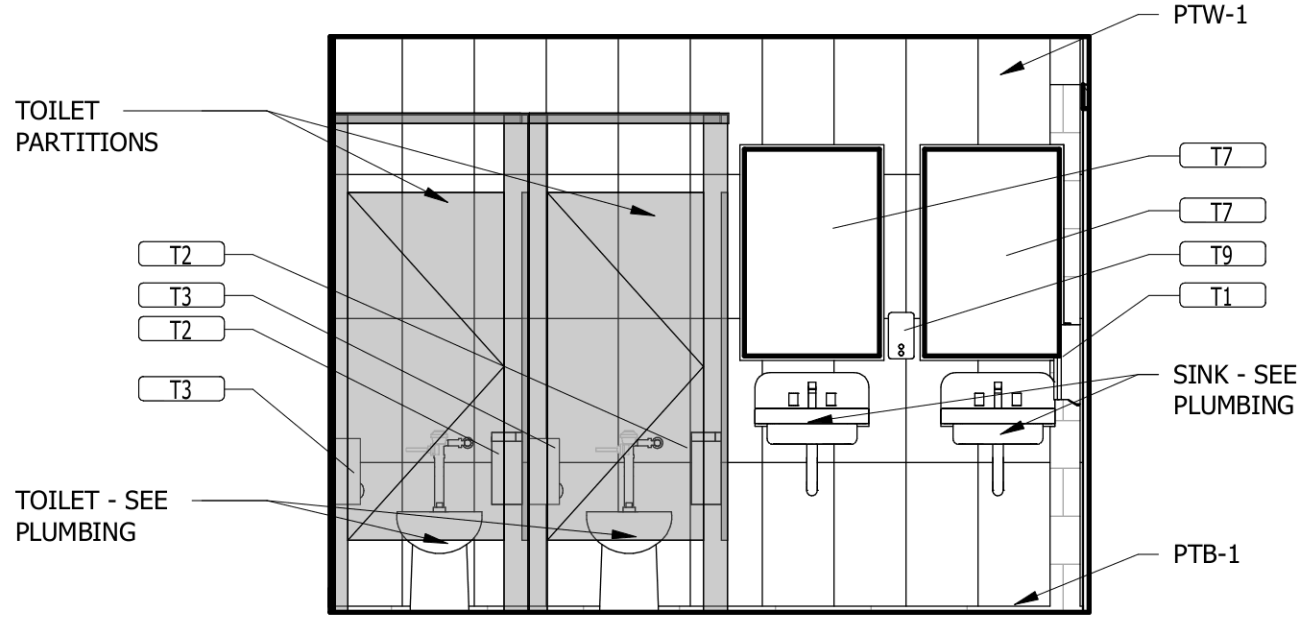


2 INT. ELEV. 2 @ WOMEN 5
3/8" = 1'-0"

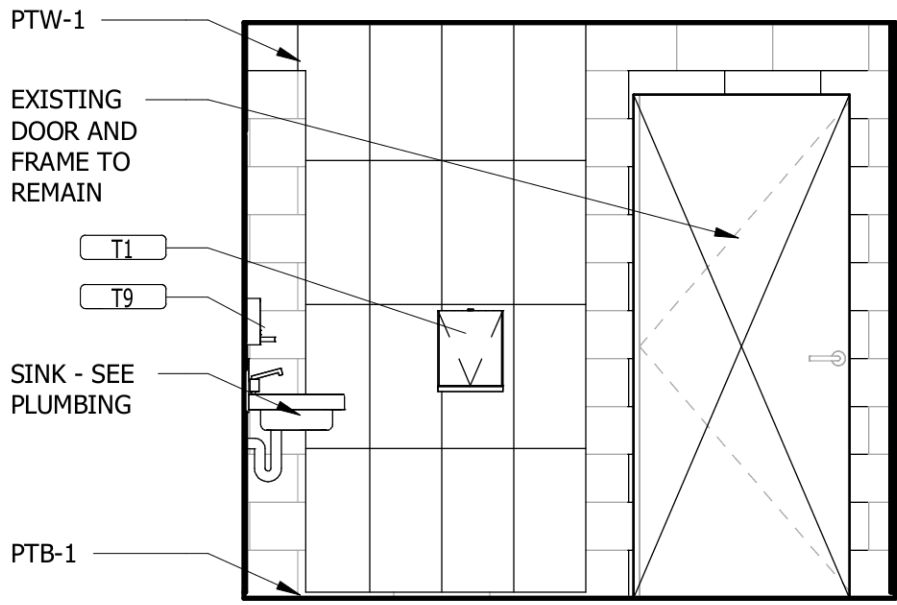


3 INT. ELEV. 3 @ WOMEN 5
3/8" = 1'-0"

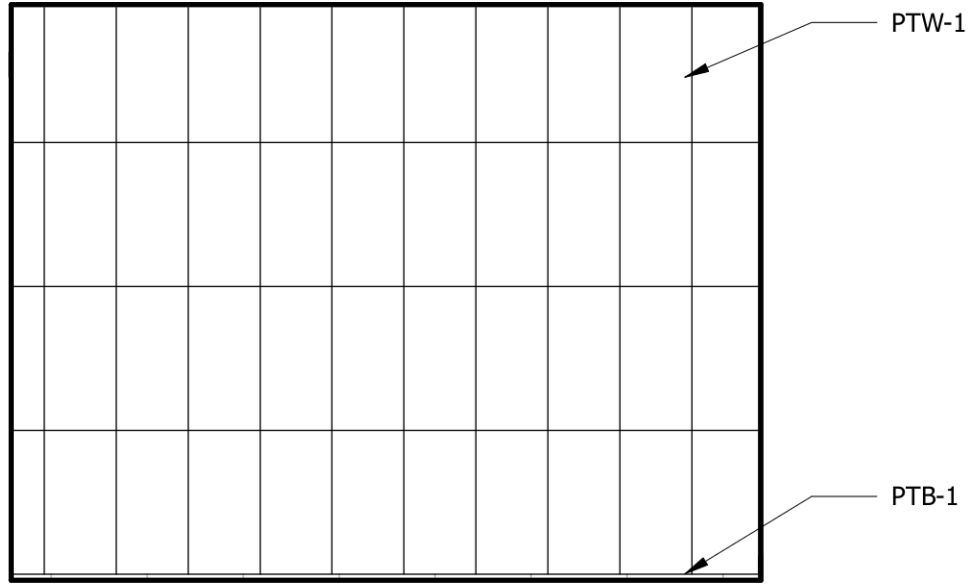


4 INT. ELEV. 4 @ WOMEN 5
3/8" = 1'-0"

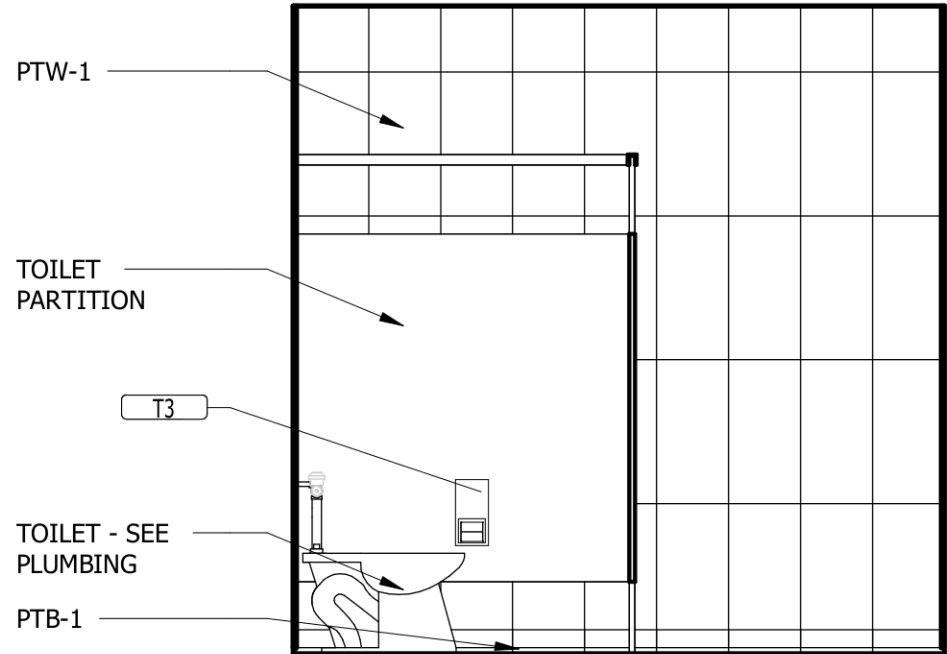


5 INT. ELEV. 1 @ MEN 9
3/8" = 1'-0"

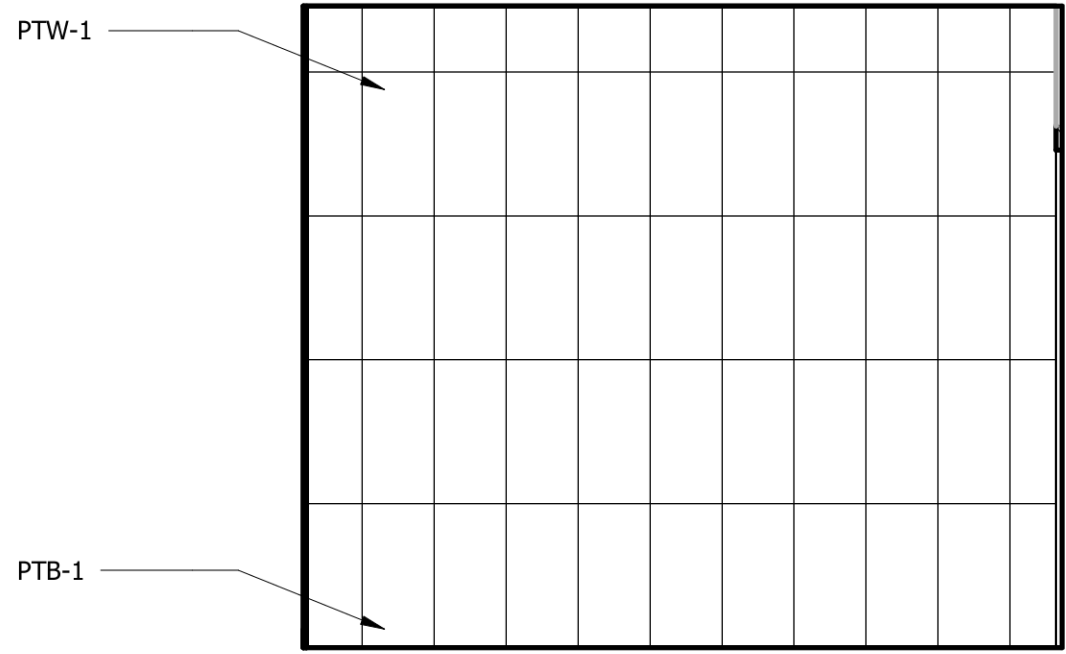

6 INT. ELEV. 2 @ MEN 9
3/8" = 1'-0"

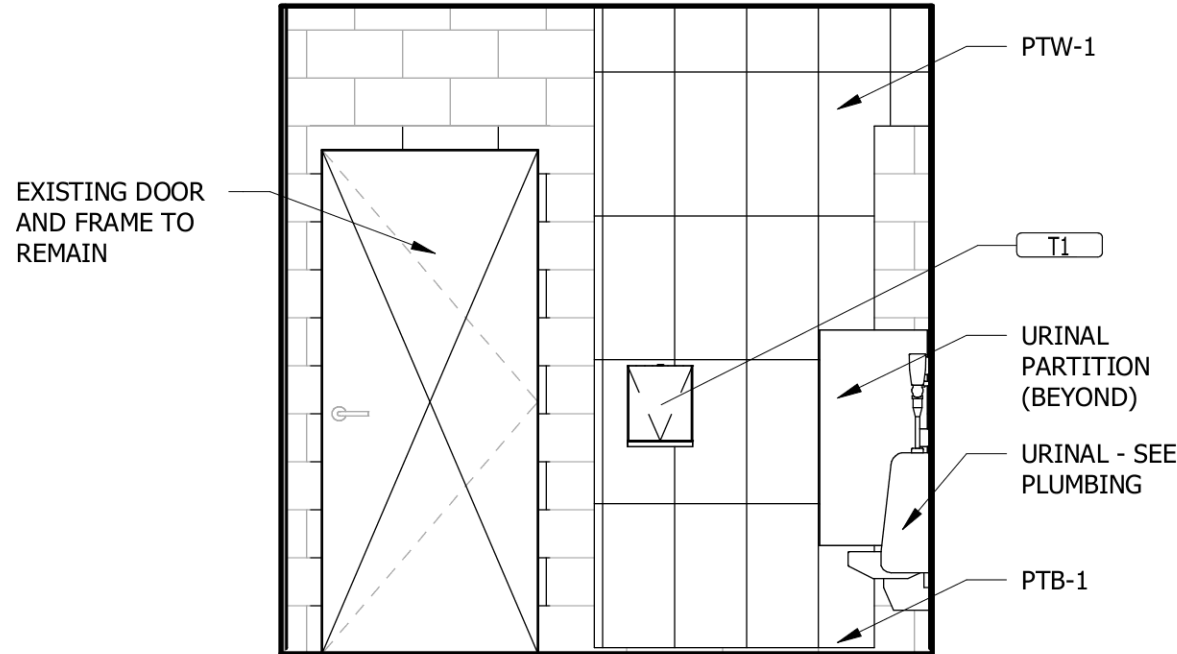


7 INT. ELEV. 3 @ MEN 9
3/8" = 1'-0"

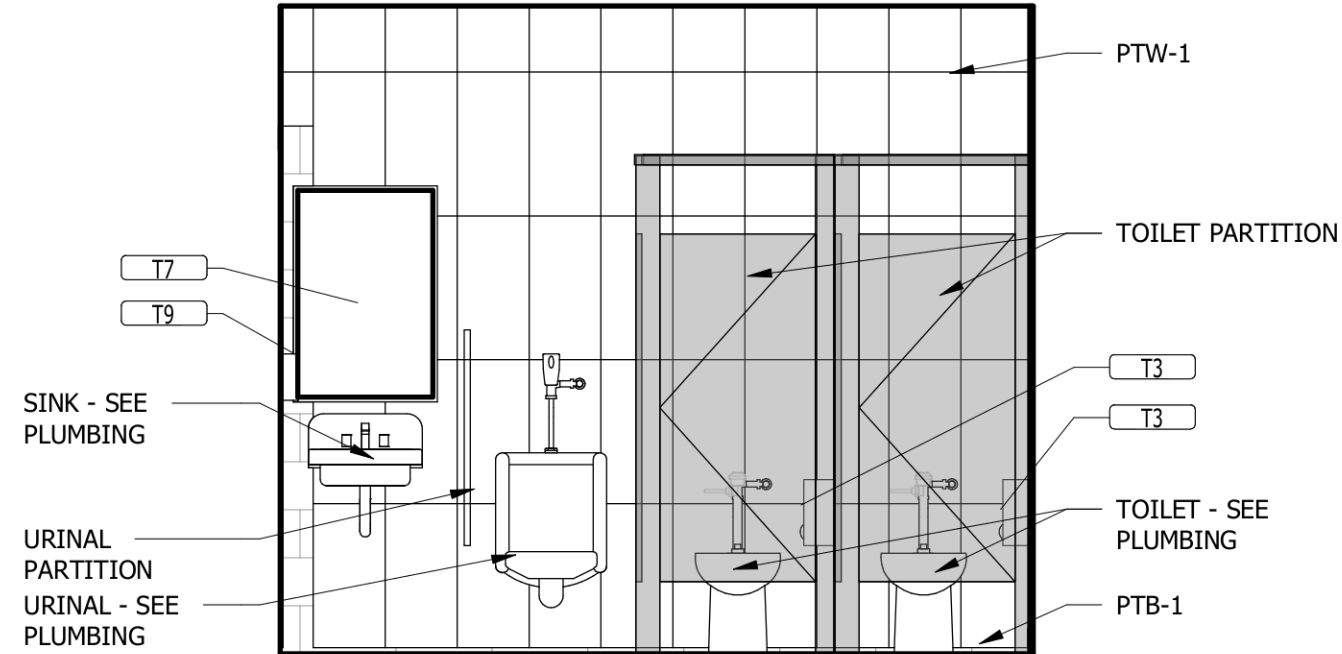

8 INT. ELEV. 4 @ MEN 9
3/8" = 1'-0"

ADA MOUNTING HEIGHTS - TOILET ACCESSORIES

- NOTE:
1. ALL ITEMS SHOWN MAY OR MAY NOT BE APPLICABLE TO THIS PROJECT. REFER TO ENLARGED TOILET ROOM PLANS FOR ACTUAL ACCESSORIES USED. PROVIDE BLOCKING AS REQUIRED.
2. EQUIPMENT AND DISPENSERS ARE BY OWNER UNLESS INDICATED OTHERWISE.
3. ADA STALL DOOR TO HAVE PULL ON BOTH SIDES OF DOOR.

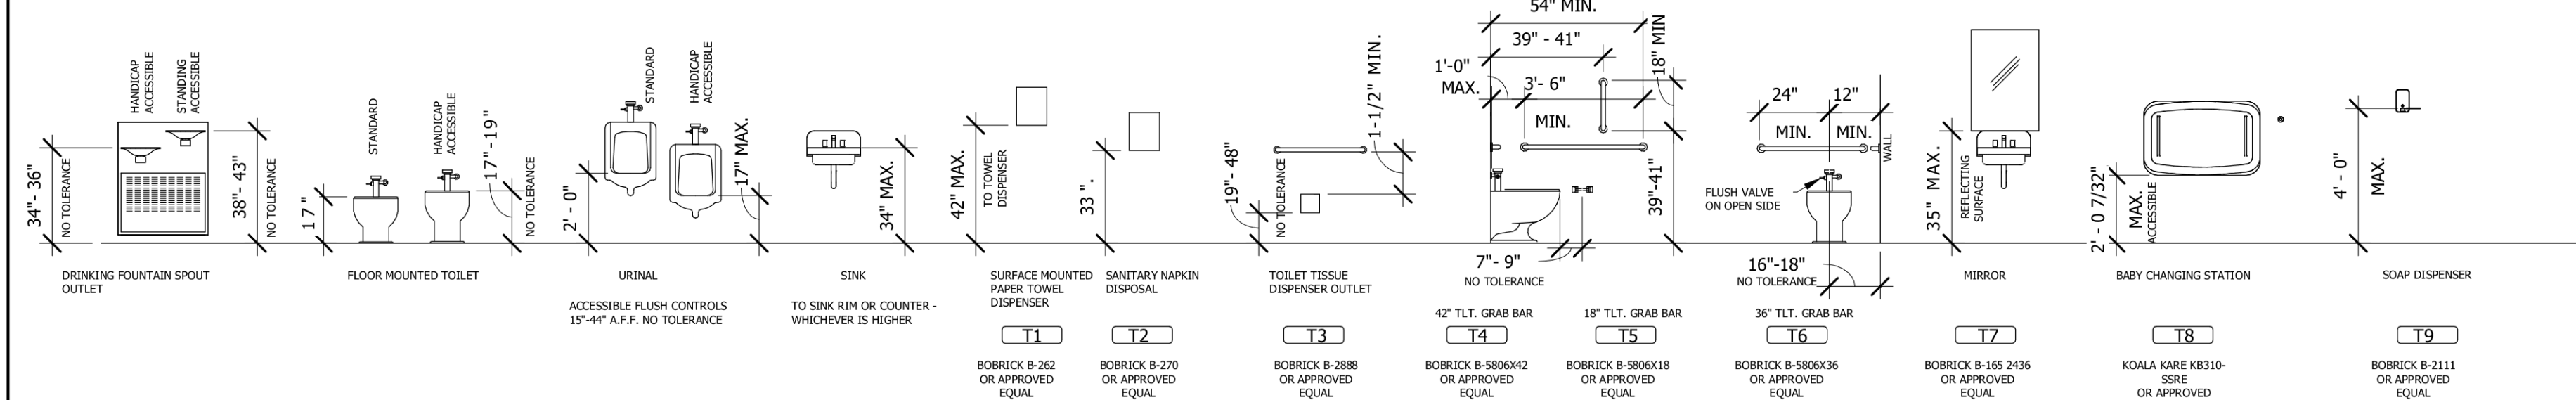

TOILET ACCESSORIES SCHEDULE

Type Mark	Type	Comments
T1	PAPER TOWEL DISPENSER	OWNER FURNISHED OWNER INSTALLED
T2	SANITARY NAPKIN DISPOSAL	
T3	TOILET PAPER DISPENSER	OWNER FURNISHED OWNER INSTALLED
T4	GRAB BAR - 42"	
T5	GRAB BAR - 18"	
T6	GRAB BAR - 36"	
T7	MIRROR - 24" x 36"	
T8	BABY CHANGING STATION	
T9	SOAP DISPENSER	OWNER FURNISHED OWNER INSTALLED

LIBRARY RESTROOM RENOVATION

SBC PROJECT NUMBER 166/019-01-2025

42 JACKSON STATE DRIVE,
JACKSON, TN 38301

JACKSON STATE COMMUNITY COLLEGE


No.	Revision Description	Date

INTERIOR ELEVATIONS AND DETAILS


JOB NO: 63745 DRAWN: ASB
DATE: 07.15.2026 CONSTRUCTION DOCUMENTS

A11.1


Plotted on: 8/21/2026 1:55:39 PM

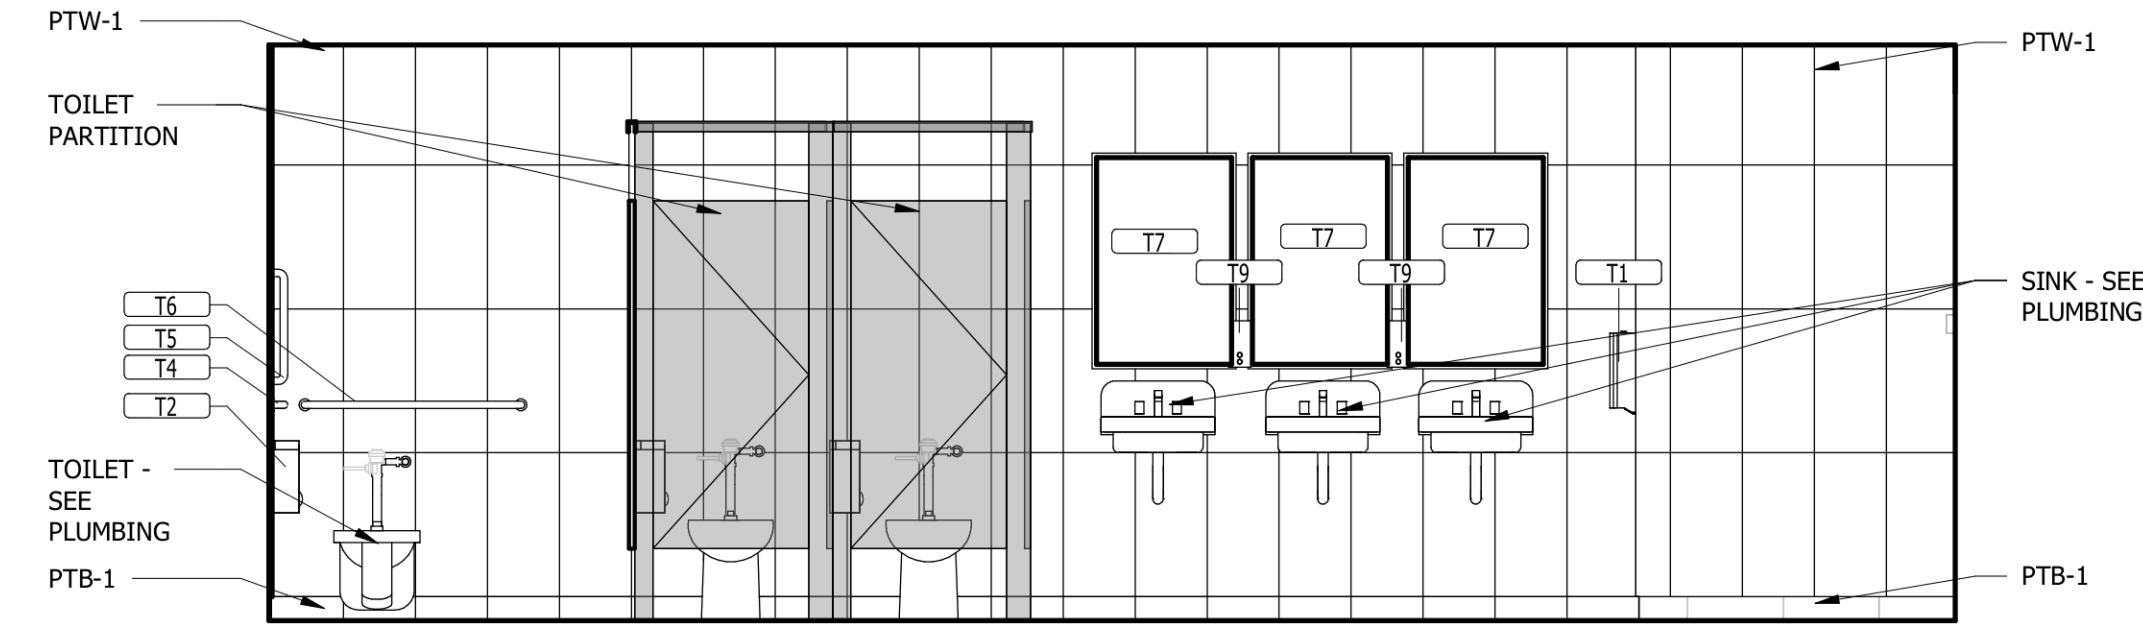


1 INT. ELEV. 1 @ WOMEN 22
3/8" = 1'-0"

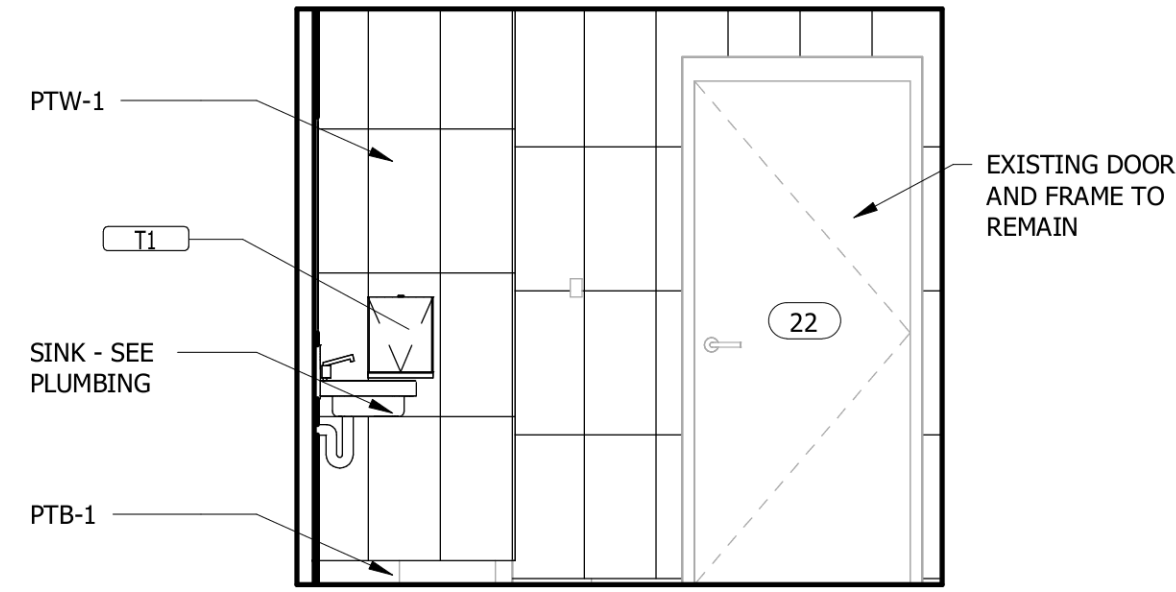


2 INT. ELEV. 2 @ WOMEN 22
3/8" = 1'-0"

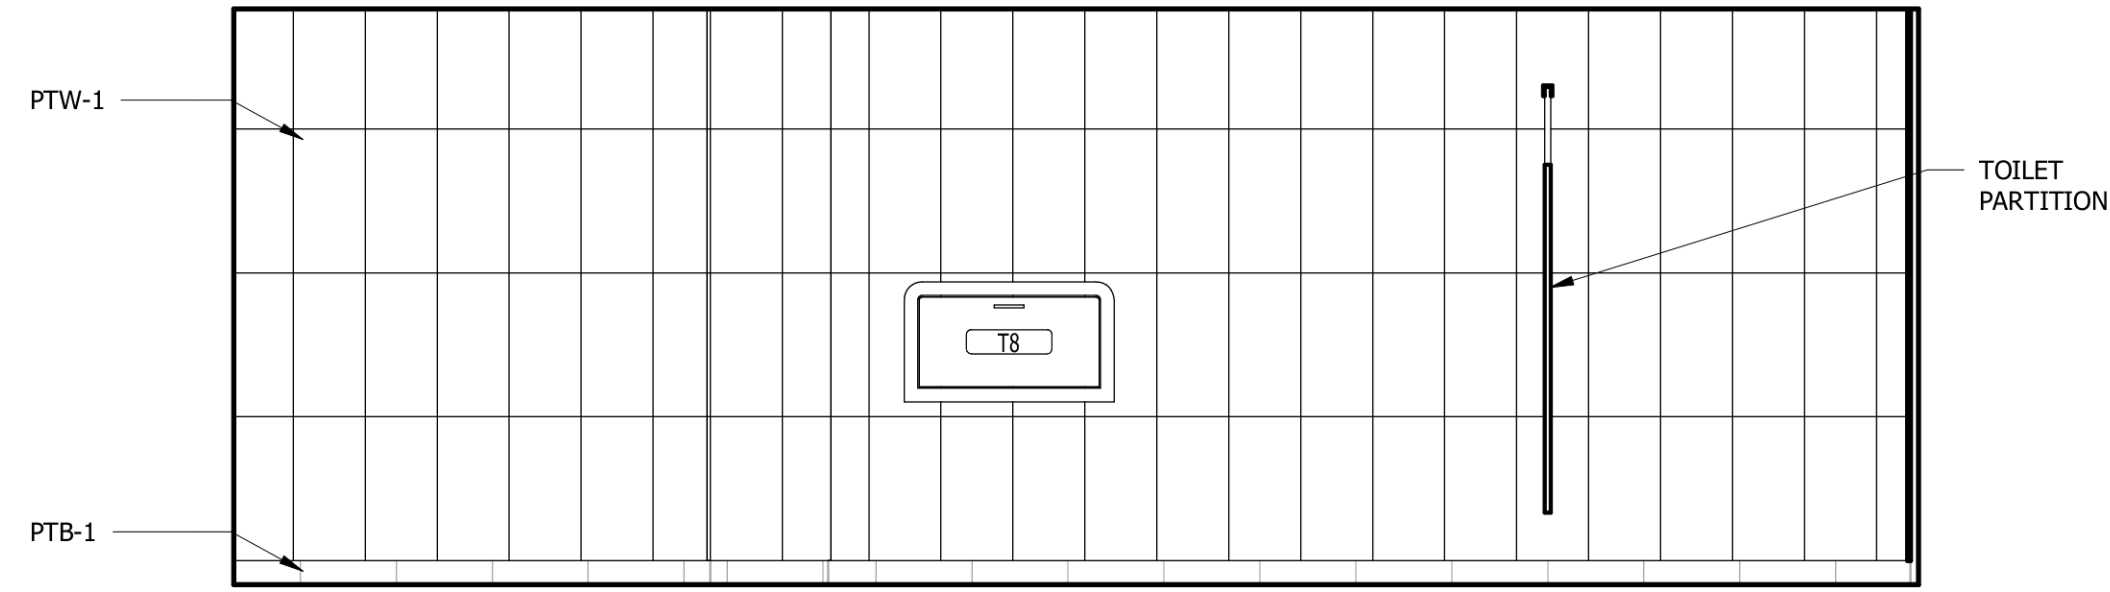


3 INT. ELEV. 3 @ WOMEN 22
3/8" = 1'-0"

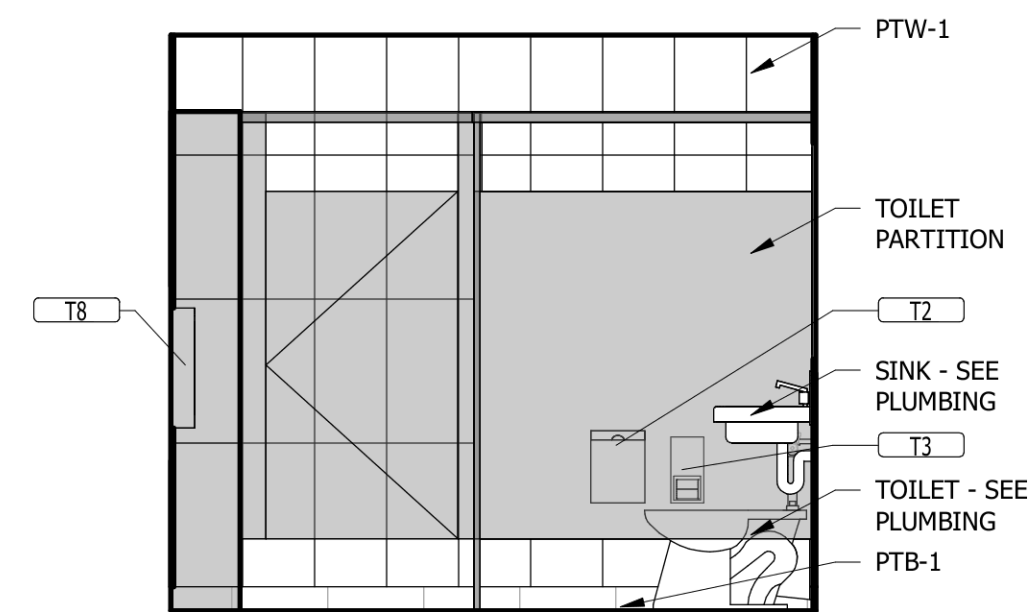


4 INT. ELEV. 4 @ WOMEN 22
3/8" = 1'-0"

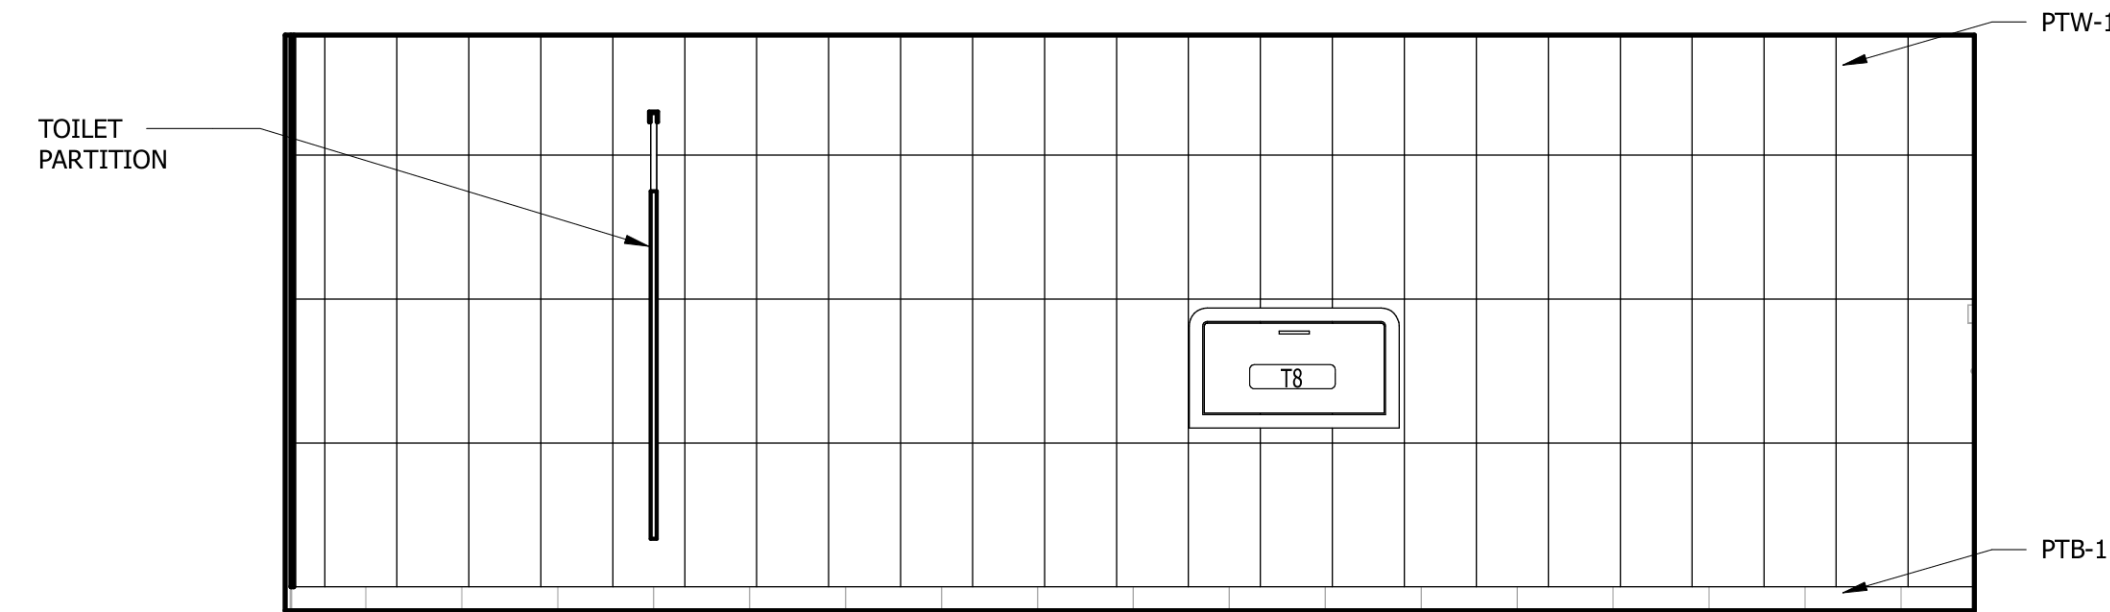


5 INT. ELEV. 1 @ MEN 24
3/8" = 1'-0"

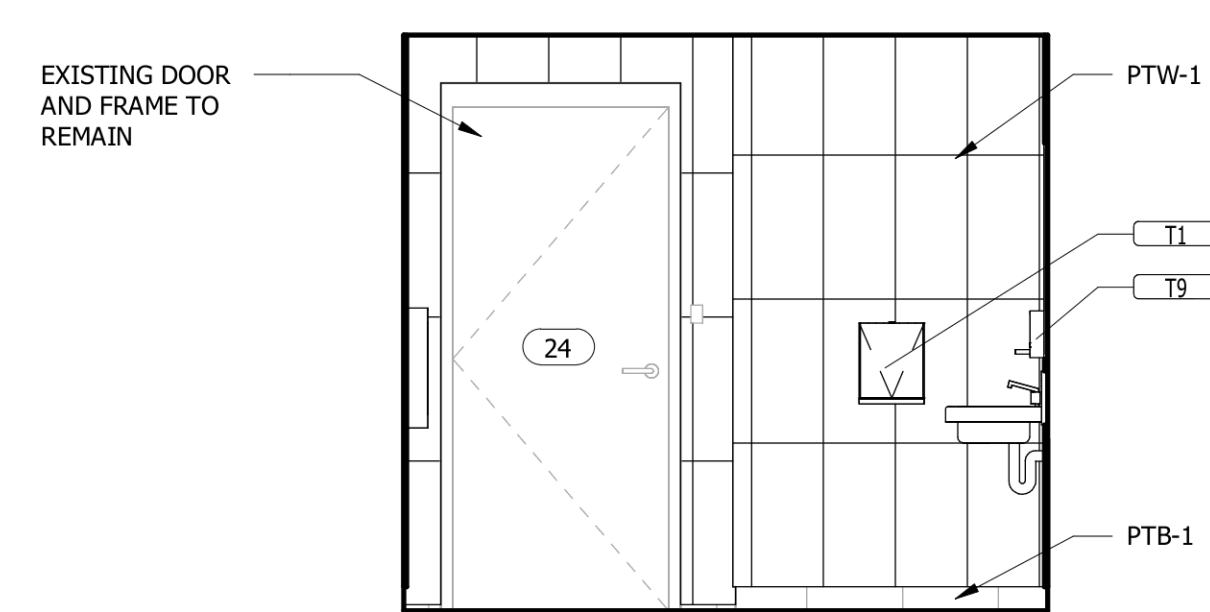

6 INT. ELEV. 2 @ MEN 24
3/8" = 1'-0"

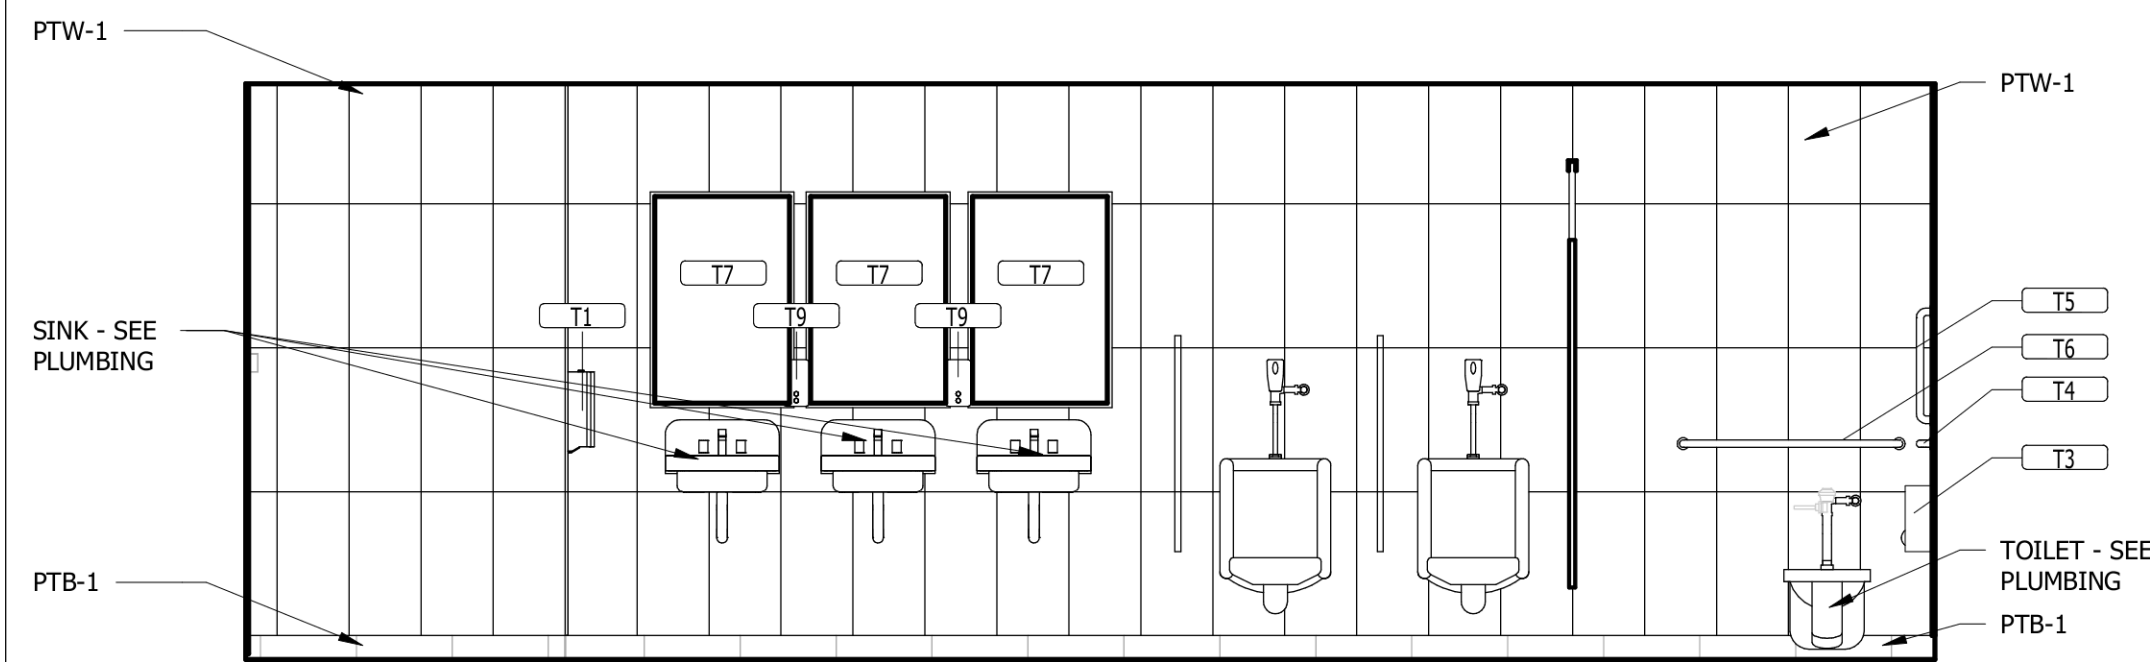

7 INT. ELEV. 3 @ MEN 24
3/8" = 1'-0"

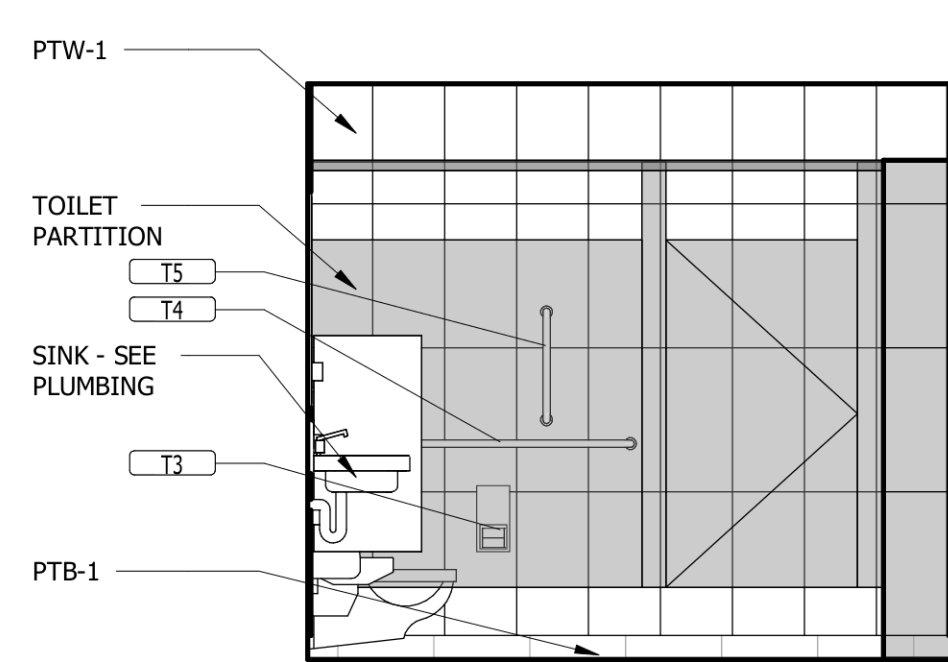

8 INT. ELEV. 4 @ MEN 24
3/8" = 1'-0"


TOILET ACCESSORIES SCHEDULE		
Type Mark	Type	Comments
T1	PAPER TOWEL DISPENSER	OWNER FURNISHED OWNER INSTALLED
T2	SANITARY NAPKIN DISPOSAL	OWNER FURNISHED OWNER INSTALLED
T3	TOILET PAPER DISPENSER	OWNER FURNISHED OWNER INSTALLED
T4	GRAB BAR - 42"	
T5	GRAB BAR - 18"	
T6	GRAB BAR - 36"	
T7	MIRROR - 24" x 36"	
T8	SOAP DISPENSER	OWNER FURNISHED OWNER INSTALLED
T9		



Allen&Hoshall
engineers • architects • surveyors

Allen & Hoshall
1661 International Drive, Suite 100
Memphis, TN 38120
901 820 0820 fax 866 270 6330

© ALLEN & HOSHALL
This document is proprietary and shall not be reproduced or used by others without prior written consent. These drawings are intended to be plotted in color. Contractor assumes all risk in utilizing these drawings in any other manner.

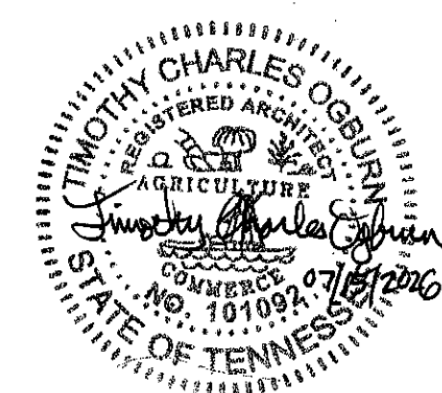

LIBRARY RESTROOM RENOVATION

SBC PROJECT NUMBER 166/019-01-2025

42 JACKSON STATE DRIVE,
JACKSON, TN 38301

JACKSON STATE COMMUNITY COLLEGE

No.	Revision	Description	Date

INTERIOR ELEVATIONS AND DETAILS

JOB NO: 63745 DRAWN: ASB
DATE: 07.15.2026 CONSTRUCTION DOCUMENTS



A11.2



Allen&Hoshall
engineers • architects • surveyors

Allen & Hoshall
1661 International Drive, Suite 100
Memphis, TN 38120
901 820 0820 fax 866 270 6330

© ALLEN & HOSHALL
This document is proprietary and shall not be reproduced or used by others without prior written consent. These drawings are intended to be plotted in color. Contractor assumes all risk in utilizing these drawings in any other manner.

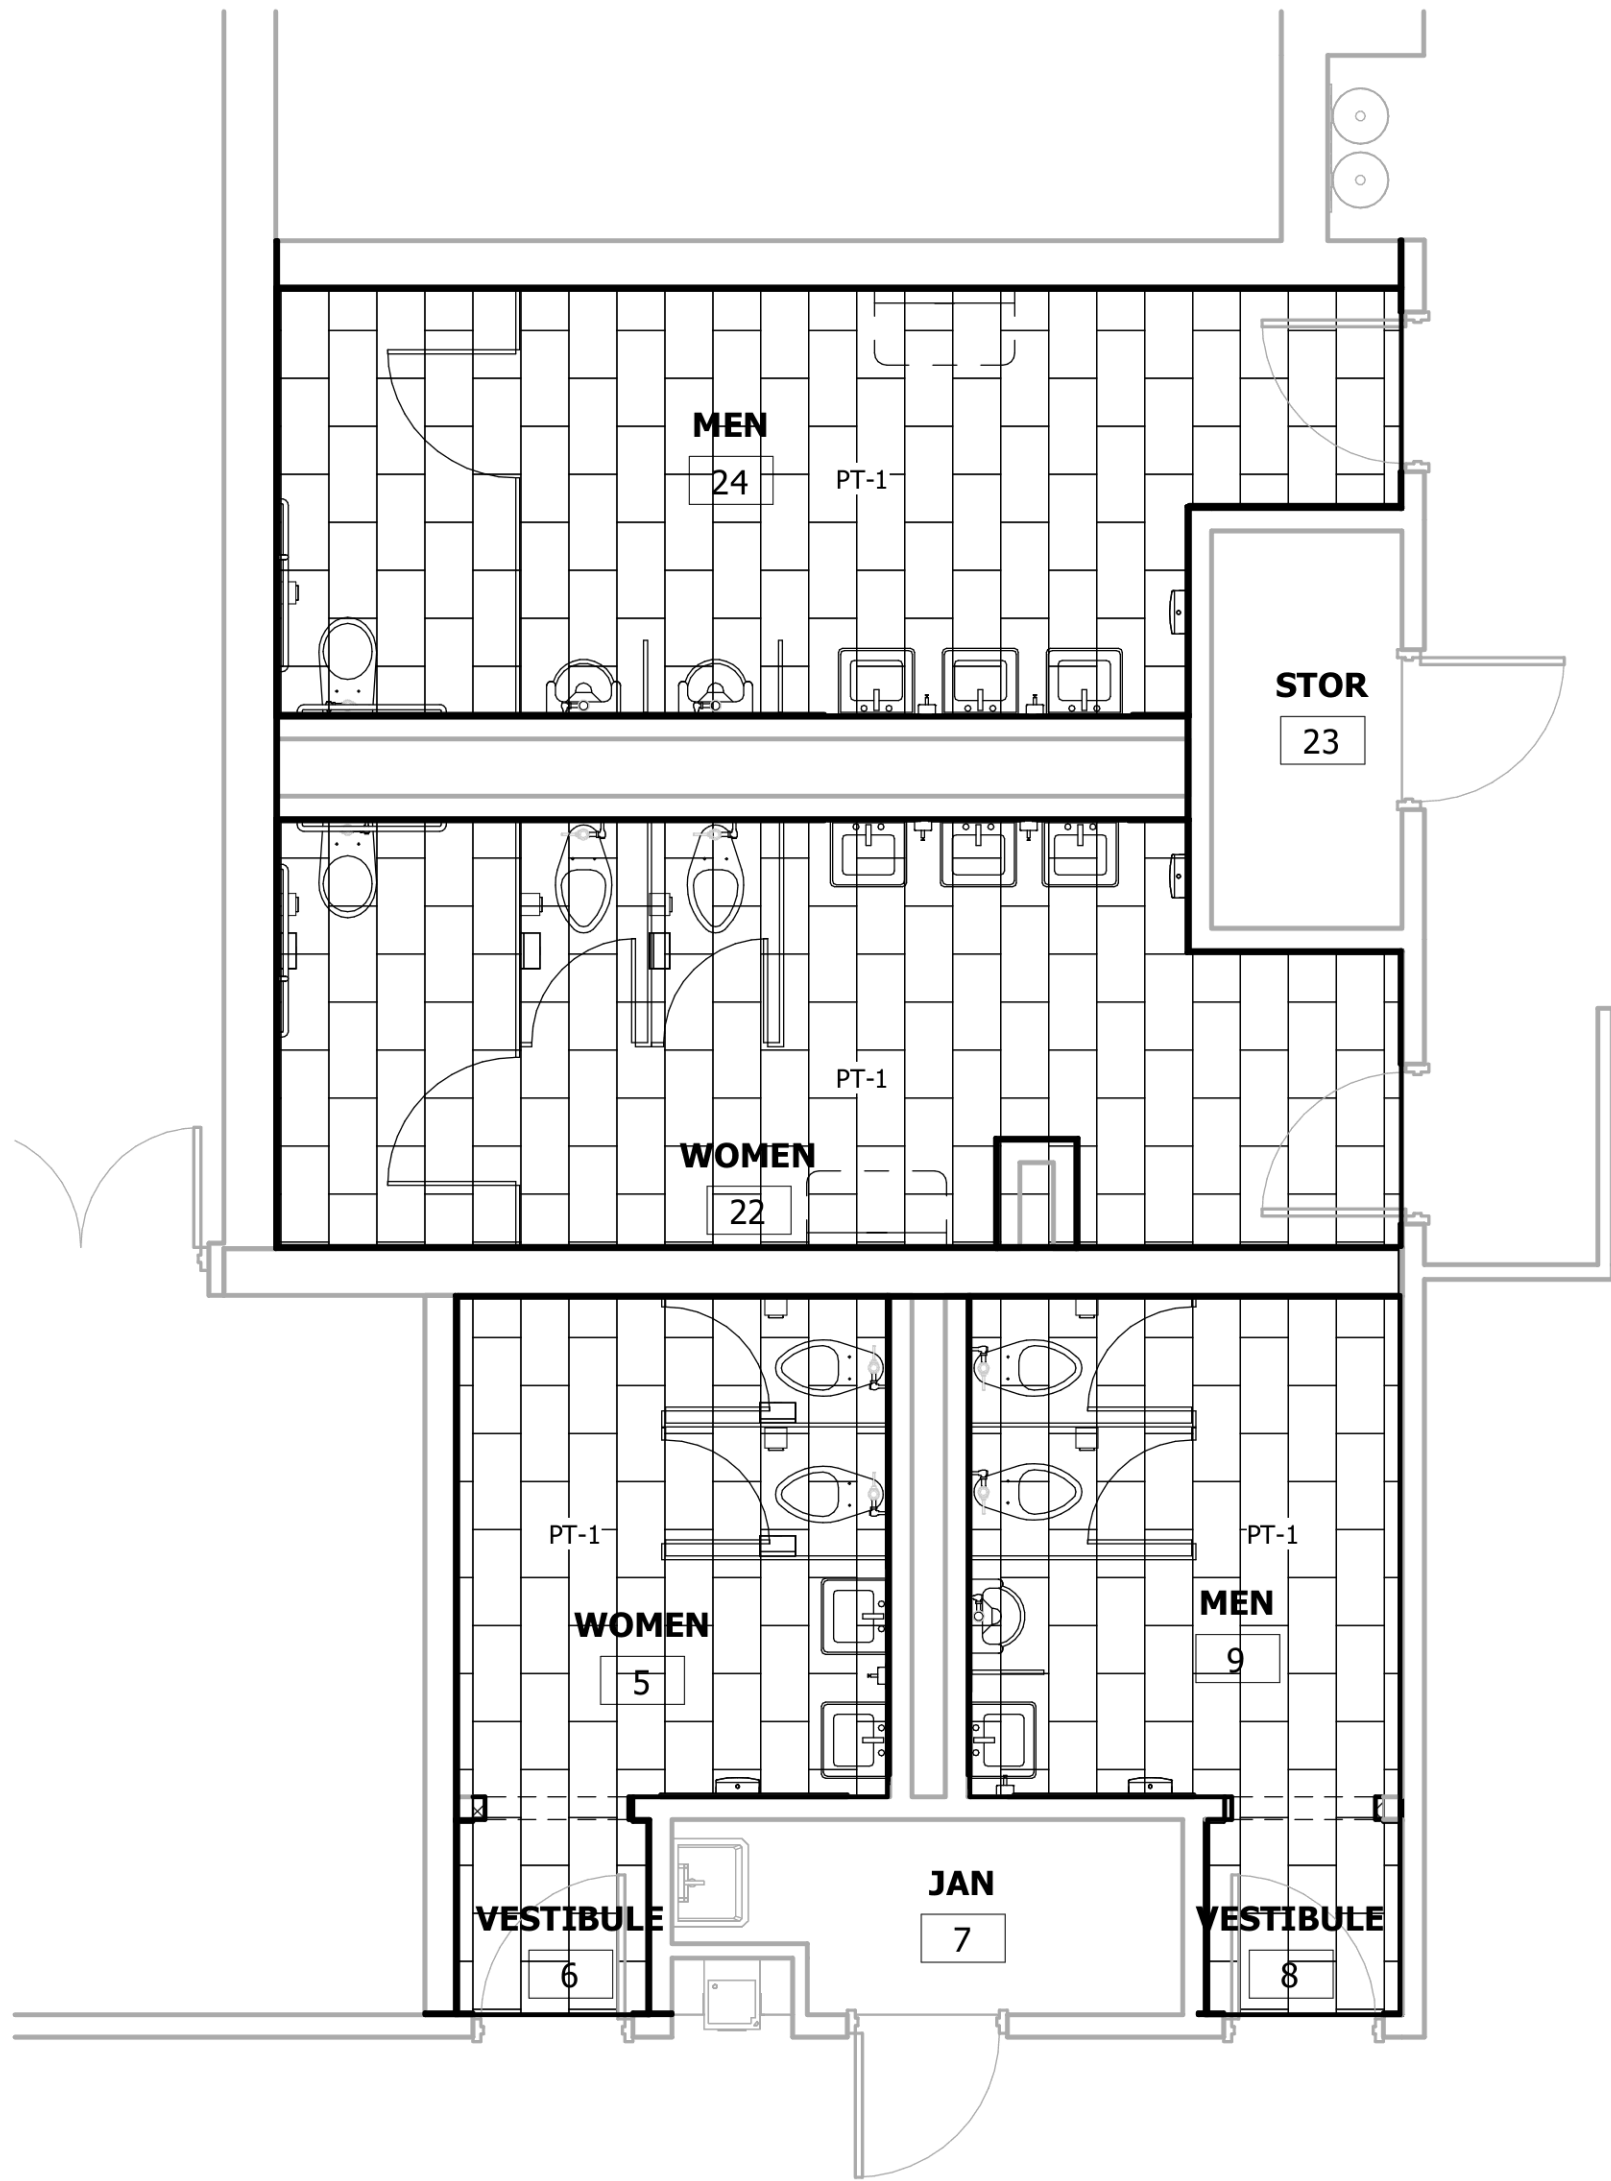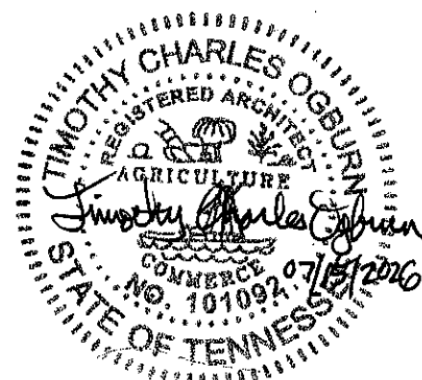

1 FINISH PLAN
1/4" = 1'-0"

ROOM / FINISH SCHEDULE								
NUMBER	NAME	FLOOR	BASE	N. WALL	E. WALL	S. WALL	W. WALL	Comments
5	WOMEN	PT-1	PTB-1	PTW-1	PTW-1	PTW-1	PTW-1	
6	VESTIBULE	PT-1	PTB-1	PNT-1	PNT-1	PNT-1	PNT-1	
7	JAN	-	-	-	-	-	-	
8	VESTIBULE	PT-1	PTB-1	PNT-1	PNT-1	PNT-1	PNT-1	
9	MEN	PT-1	PTB-1	PTW-1	PTW-1	PTW-1	PTW-1	
22	WOMEN	PT-1	PTB-1	PTW-1	PTW-1	PTW-1	PTW-1	
23	STOR	-	-	-	-	-	-	
24	MEN	PT-1	PTB-1	PTW-1	PTW-1	PTW-1	PTW-1	

FINISH LEGEND		
FLOOR	DOORS AND FRAMES	
PT - 1	PORCELAIN TILE (FIELD) MANUF: ATLAS CONCORDE STYLE: COVE MATTE COLOR: STORM SIZE: 12" X 24" INSTALL: HALF LAP GROUT: LATICRETE, ANTIQUE WHITE	HOLLOW METAL DOORS AND FRAMES DOOR & FRAME PAINT MANUF: SHERWIN WILLIAMS COLOR: ANEW GRAY
BASE	TOILET COMPARTMENTS	
PTB-1	PORCELAIN TILE COVE BASE MANUF: ATLAS CONCORDE STYLE: COVE MATTE COLOR: STORM	TOILET COMPARTMENTS MANUF: ASI TOILET PARTITIONS COLOR: MOSS
WALL	CEILING	
PNT - 1 ENAMEL	WALL PAINT 1 (FIELD) MANUF: SHERWIN WILLIAMS COLOR: ANEW GRAY	PNT - 2 ENAMEL CEILING PAINT 2 (FIELD) MANUF: SHERWIN WILLIAMS COLOR: AGGREEABLE GRAY
PTW-1	PORCELAIN WALL TILE 1 MANUF: ATLAS CONCORDE STYLE: COVE MAT COLOR: PEBBLE INSTALL: VERTICAL STACK GRID GROUT: LATICRETE, ANTIQUE WHITE	
FINISH NOTES		
1. CONTRACTOR TO VERIFY PAINT COLORS WITH OWNER BY INSTALLING A FIELD SAMPLE OR SAMPLES PRIOR TO BEGINNING INSTALLATION. 2. COORDINATE WITH OWNER FOR LOCATION TO STORE ADDITIONAL STOCK ITEMS.		

LIBRARY RESTROOM RENOVATION

SBC PROJECT NUMBER 166/019-01-2025

42 JACKSON STATE DRIVE,
JACKSON, TN 38301

JACKSON STATE COMMUNITY COLLEGE

No.	Revision	Description	Date

FINISH PLAN, FINISH SCHEDULE, AND FINISH LEGEND

JOB NO: 63745
DATE: 07.15.2026
DRAWN: ASB
CONSTRUCTION DOCUMENTS


A12.1



Allen&Hoshall
engineers • architects • surveyors

Allen & Hoshall
1661 International Drive, Suite 100
Memphis, TN 38120
901 820 0820 fax 866 270 6330

© ALLEN & HOSHALL
This document is proprietary and shall not be reproduced or used by others without prior written consent. These drawings are intended to be plotted in color. Contractor assumes all risk in utilizing these drawings in any other manner.

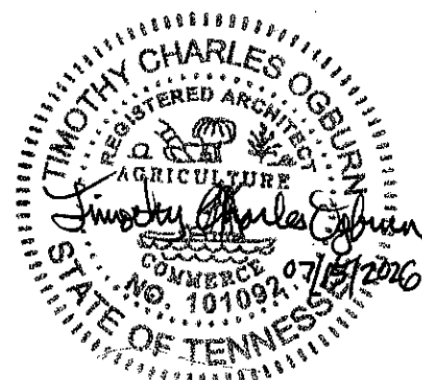

**LIBRARY RESTROOM
RENOVATION**

SBC PROJECT NUMBER 166/019-01-2025

42 JACKSON STATE DRIVE,
JACKSON, TN 38301


JACKSON STATE COMMUNITY COLLEGE

No.	Revision Description	Date
-----	----------------------	------


DEMOLITION PLAN

JOB NO: 63745 DRAWN: ASB
DATE: 07.15.2026 CONSTRUCTION DOCUMENTS

AD1.0

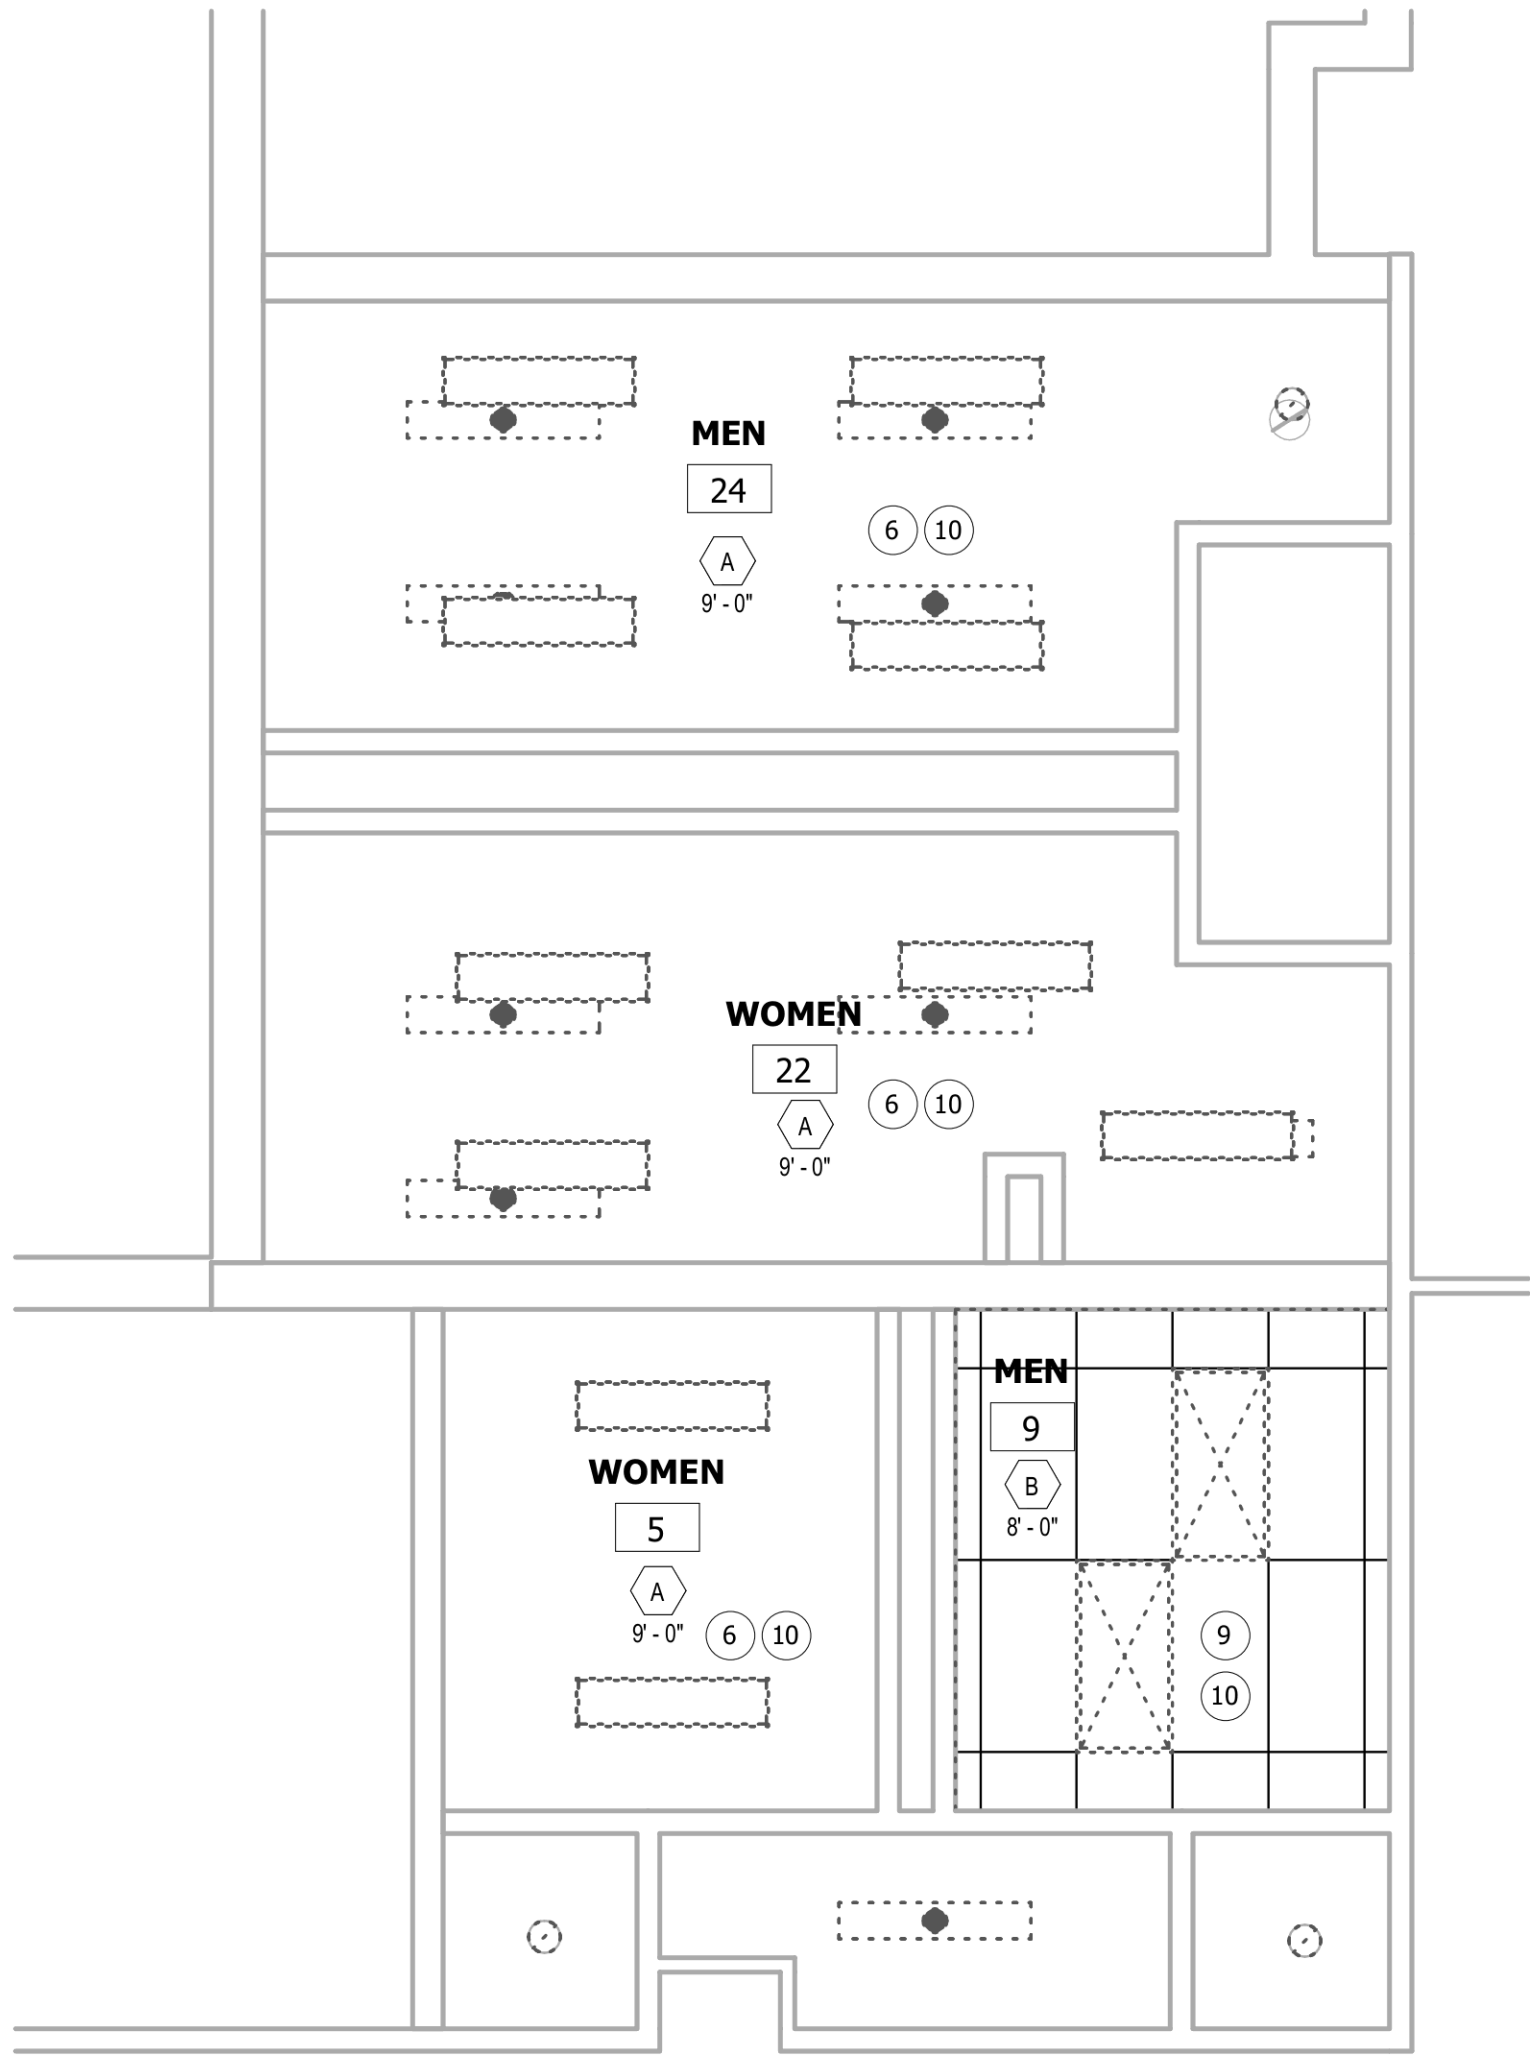


2 FIRST FLOOR - DEMOLITION REFLECTED CEILING PLAN
1/4" = 1'-0"

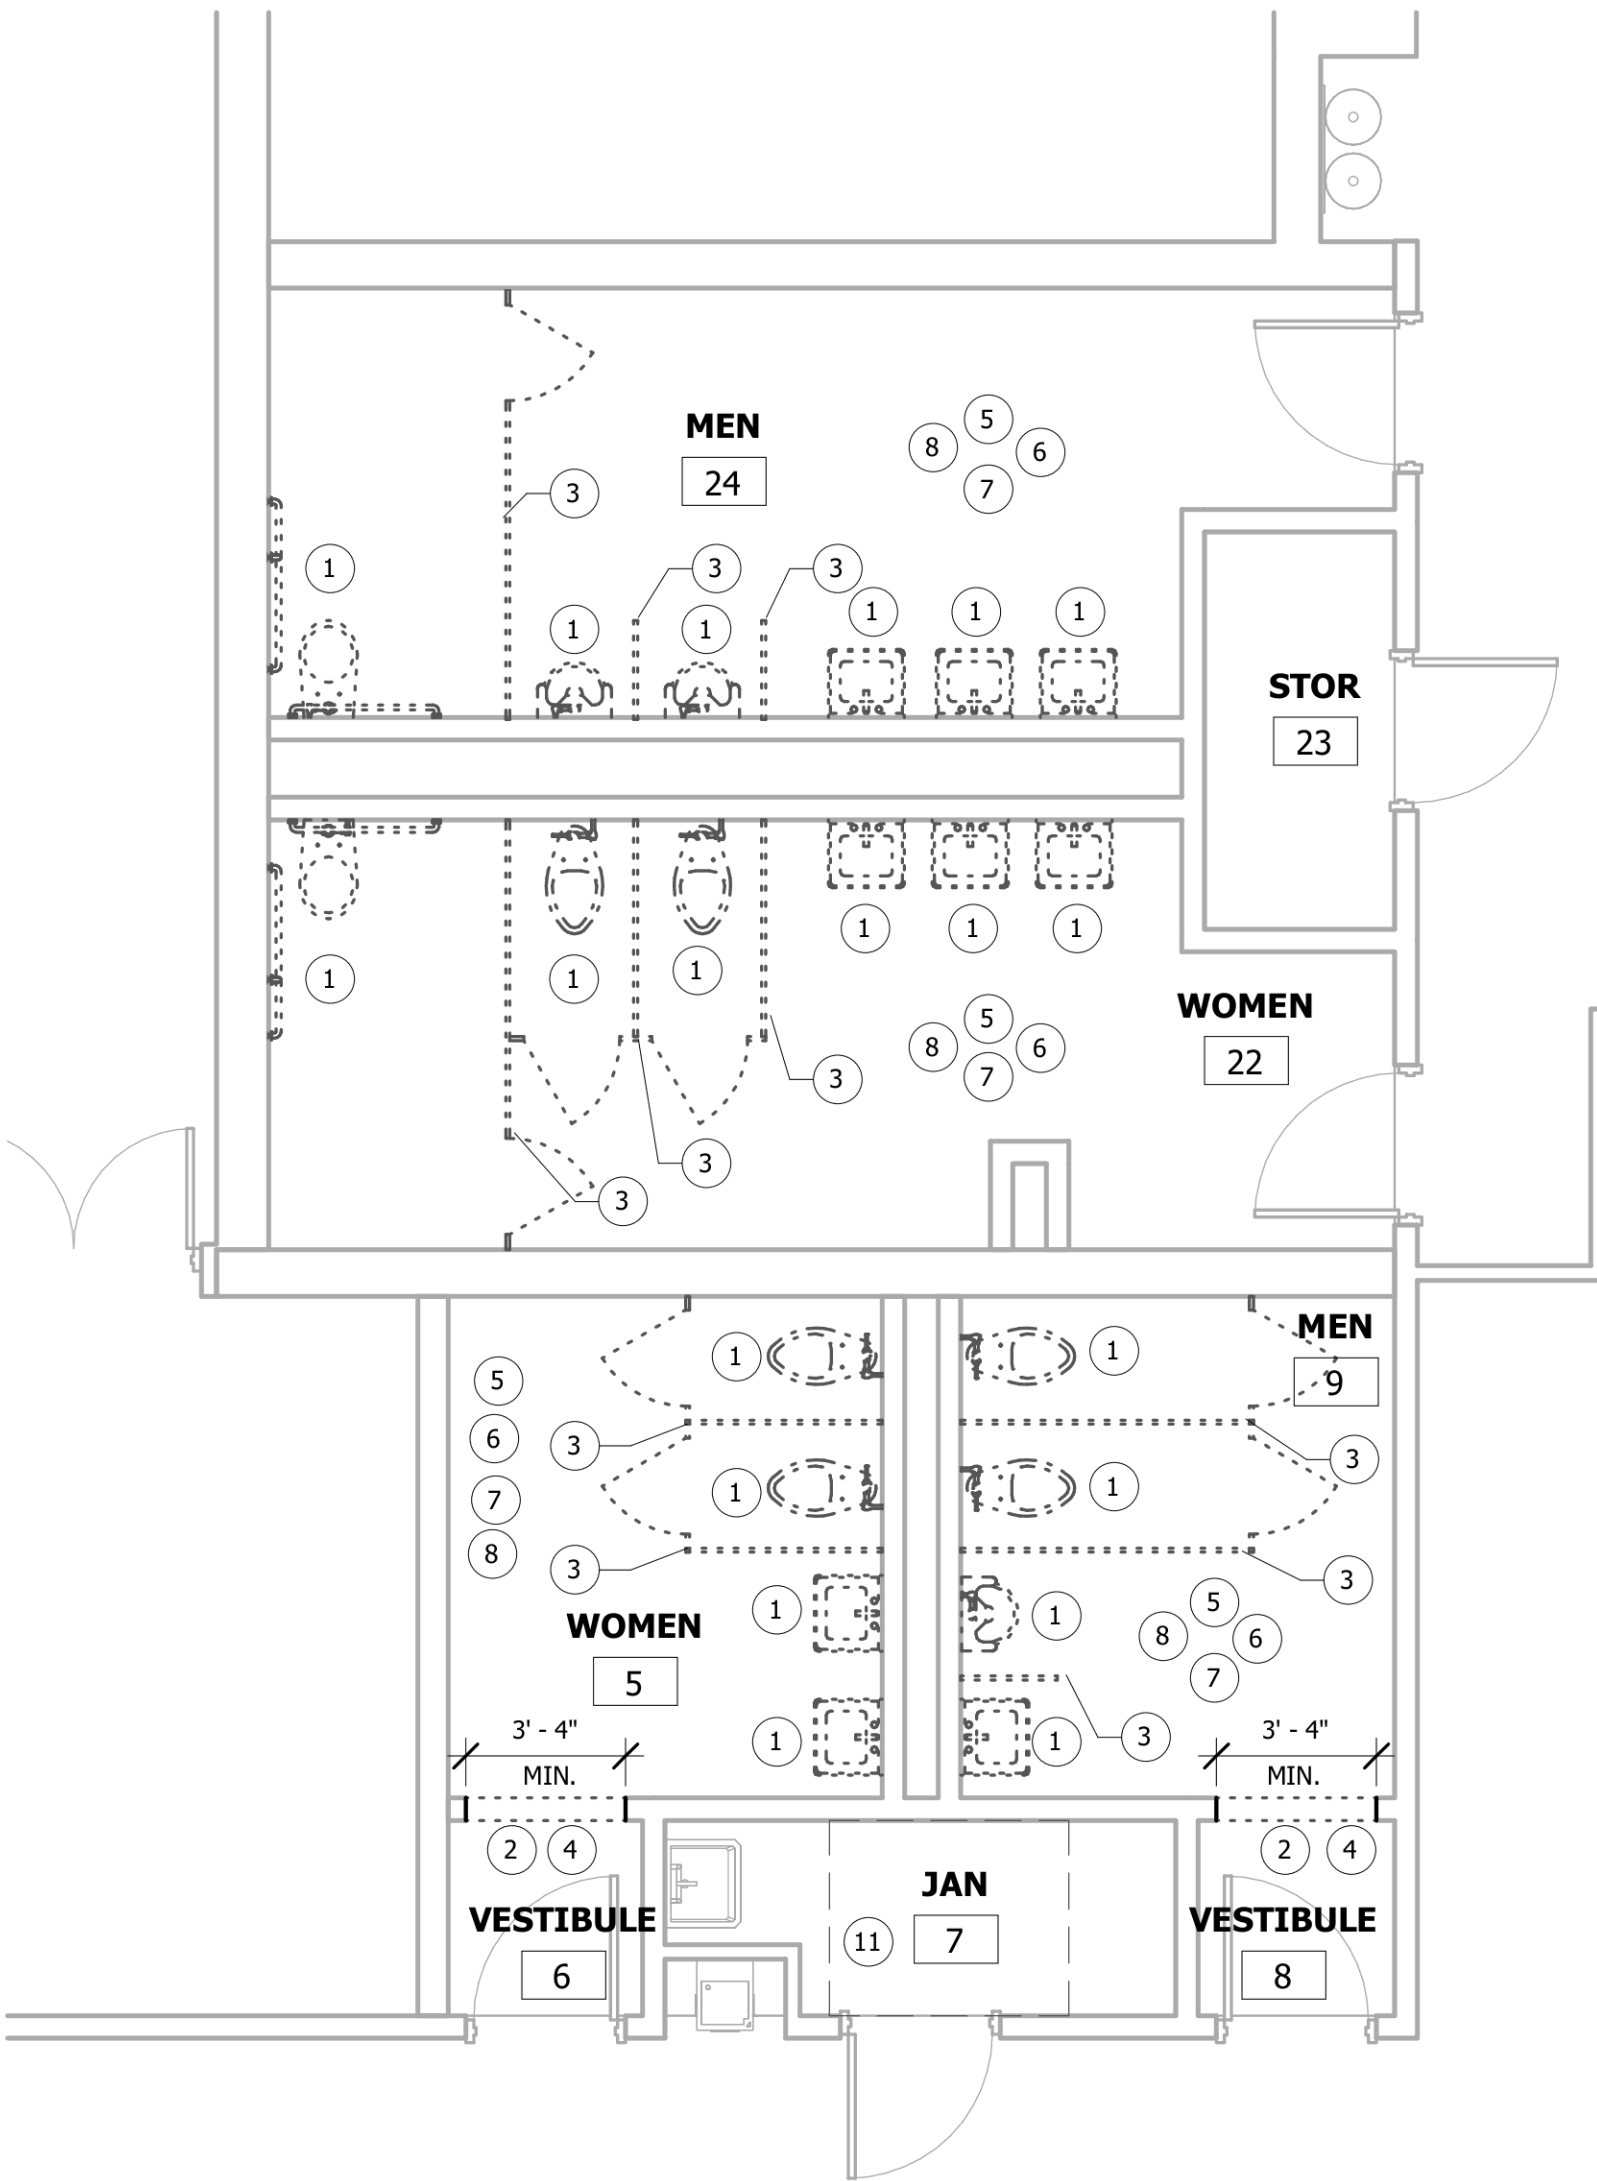

1 DEMOLITION PLAN
1/4" = 1'-0"

 DEMOLITION LEGEND



NO WORK IN THIS AREA

NOTE: DASHED LINES INDICATE AREAS OR ITEMS TO BE DEMOLISHED

- 1 REMOVE EXISTING PLUMBING FIXTURES. REFERENCE PLUMBING DRAWINGS. PREPARE SUBSTRATE TO RECEIVE NEW FINISHES.
- 2 REMOVE EXISTING DOOR AND FRAME. REPAIR BLOCK WHERE FRAMES HAVE BEEN DEMOLISHED. PREPARE SUBSTRATE TO RECEIVE NEW FINISHES. INCLUDING HEADERS AT DOORWAYS.
- 3 REMOVE EXISTING TOILET PARTITIONS AND ACCESSORIES.
- 4 REMOVE PORTION OF EXISTING WALL AS DIMENSIONED TO CREATE AN OPENING PER NEW PLANS.
- 5 REMOVE EXISTING TILE FLOORING AND BASE. PREP FOR NEW FINISHES.
- 6 CLEAN AND PREP CEILING FOR NEW FINISHES. REPAIR ANY DAMAGED CEILINGS TO REMAIN. REMOVE ANY CEILING REQUIRED TO ACCOMMODATE NEW FIXTURES.
- 7 CLEAN AND PREP EXISTING WALLS FOR NEW FINISHES, REPAIR ANY DAMAGED WALLS TO REMAIN.
- 8 REMOVE WALL AND PARTITION MOUNTED ACCESSORIES SUCH AS MIRRORS, CHANGING STATIONS, PAPER TOWEL HOLDERS, HOOKS, ETC.
- 9 REMOVE ACOUSTICAL CEILING TILE AND PREP CEILING FOR NEW FINISHES.
- 10 REMOVE EXISTING LIGHT FIXTURES AND PREP CEILING FOR NEW LIGHTING FIXTURES.
- 11 REMOVE EXISTING SLAB AND PREP FOR NEW WORK. CLEAN AND MATCH EXISTING.

DEMO GENERAL NOTES

1. CONTRACTOR SHALL FIELD VERIFY ALL EXISTING CONDITIONS AND REPORT ANY DISCREPANCIES TO THE ARCHITECT PRIOR TO THE COMMENCEMENT OF WORK.
2. CONTRACTOR TO NOTIFY OWNER IF SUSPECTED ASBESTOS IS FOUND.
3. CONTRACTOR SHALL RETAIN ALL REQUIRED EGRESS PASSAGES AND EMERGENCY LIGHTING THROUGHOUT THE DURATION OF THE WORK.
4. CONTRACTOR SHALL PROVIDE TEMPORARY BARRIERS TO PREVENT UNAUTHORIZED ACCESS TO CONSTRUCTION AREAS DURING THE DURATION OF THE WORK.
5. REMOVAL OF ANY PARTITION SHALL NOT EXPOSE THE FLOOR TO AN UNPROTECTED STATE. REPAIR AND/OR REPLACE AS REQUIRED.
6. REFER TO PLUMBING AND ELECTRICAL SHEETS FOR ADDITIONAL INFORMATION.
7. TOOTH ALL MASONRY INTO NEW OPENINGS AS REQUIRED.
8. PATCH & REPAIR ANY DAMAGED WALLS AND FLOORING. PREP FOR NEW FINISHES.
9. REPLACE, PATCH & REPAIR ANY CEILINGS DAMAGED DURING DEMOLITION.
10. IF EXISTING ITEMS IN WORKING ORDER PRIOR TO DEMOLITION ARE DAMAGED DURING CONSTRUCTION AND ARE TO BE REUSED, THE ITEM(S) SHALL BE RESTORED TO WORKING ORDER AND FINISHED OR REPLACED BY THE CONTRACTOR AT NO COST TO THE OWNER.
11. ANY FINISHES, EQUIPMENT, FURNISHINGS, ETC. THAT ARE DAMAGED OR MISPLACED/LOST DURING THE COURSE OF THE WORK SHALL BE REPLACED BY THE CONTRACTOR AT NO COST TO THE OWNER.
12. WHERE NO WORK IS TO TAKE PLACE, THE CONTRACTOR SHALL PROTECT ALL EXISTING FURNISHINGS AND FINISHES THROUGHOUT DEMOLITION AND RENOVATION WORK.
13. ANY DAMAGE TO EXISTING CURBS, WALKS, PAVING, UTILITIES, FENCING, OR EXTERIOR STRUCTURES AND OTHER ITEMS INDICATED TO REMAIN SHALL BE REPAIRED OR REPLACED BY THE CONTRACTOR AT NO COST TO THE OWNER.
14. DISPOSE OF ALL DEBRIS IN ACCORDANCE WITH AUTHORITIES HAVING JURISDICTION.
15. G.C. TO VERIFY LOCATIONS OF EXISTING UTILITIES SO AS TO NOT DAMAGE EXISTING SERVICES.
16. WHERE EXIST. CMU WALLS ARE BEING PARTIALLY DEMOLISHED, EXISTING CMU TO REMAIN SHALL BE CLEANED, MADE SMOOTH, & PREPPED FOR NEW FINISHES.

L E G E N D		
SYMBOL	DESCRIPTION	ABBREVIATIONS
 P - #	PIPING, ETC., TO BE REMOVED SANITARY WASTE (SW) CONNECT TO EXIST. PIPING PLUMBING FIXTURE DESIGNATION	A.F.F. ABOVE FINISHED FLOOR AB. ABOVE ARCH. ARCHITECTURAL BEL. BELOW CLG. CEILING CO. CLEANOUT DN. DOWN DWG. DRAWING ELEV. ELEVATION F.F. FINISHED FLOOR TYP. TYPICAL

FIXTURE SCHEDULE						
FIXTURE	DESCRIPTION	TRAP SIZE	MIN. SIZE CONN.			
			SW	SV	CW	HW
P-1	WATER CLOSET (STANDARD): WHITE VITREOUS CHINA, FLOOR MOUNTED, SIPHON JET ACTION, 1-1/2" TOP SPUD, 1.28 GPF, FLUSH VALVE OPERATED, ZURN Z5655-BWL1. SEAT TO BE OPEN FRONT, WHITE PLASTIC W/ CHECK HINDGE, BENEKE #523. FLUSH VALVE SHALL BE MANUALLY OPERATED, CHROME PLATED, 1.28 GPF, DIAPHRAGM-TYPE, ZURN Z6000AV-HET.	INTEGRAL	EXISTING			
P-1A	WATER CLOSET (ADA COMPLIANT): WHITE VITREOUS CHINA, WALL HUNG, SIPHON JET ACTION, 1-1/2" TOP SPUD, 1.28 GPF, FLUSH VALVE OPERATED, ZURN Z5615-BWL. SEAT TO BE OPEN FRONT, WHITE PLASTIC W/ CHECK HINDGE, BENEKE #523. FLUSH VALVE SHALL BE MANUALLY OPERATED, CHROME PLATED, 1.28 GPF, DIAPHRAGM-TYPE, ZURN Z6000AV-HET.	INTEGRAL	EXISTING			
P-2	URINAL (ADA COMPLIANT): WHITE VITREOUS CHINA, WALL MOUNTED, WASHOUT ACTION, 3/4" TOP SPUD, 1.0 GPH, FLUSH VALVE OPERATED, ZURN 5755-U. FLUSH VALVE SHALL BE MANUALLY OPERATED, CHROME PLATED, 0.125 GPF, DIAPHRAGM-TYPE, ZURN ZER6003AV-WS1.	INTEGRAL	EXISTING			
P-3	LAVATORY (ADA COMPLIANT): WHITE VITREOUS CHINA, WALL MOUNTED, 4" FAUCET CENTERS, ZURN Z5364. FAUCET SHALL BE MANUALLY OPERATED, 0.5 GPM, SINGLE CONTROL, CHROME PLATED CAST BRASS, CERAMIC DISC CARTRIDGE, ZURN Z81000-XL-3M. PROVIDE CHROME PLATED BRASS FLAT GRID STRAINER, 17 GA. TAILPIECE AND 1-1/4" P-TRAP (SLIP JOINT) PROVIDE CHROME PLATED COPPER 3/8" SUPPLY TUBES AND 1/4 TURN BALL STOPS. PROVIDE AND INSTALL AN ASSE 1070 COMPLIANT POWERS LFG480 LAVATORY TEMPERING VALVE THAT CAN OPERATE DOWN TO 0.25 GPM. COVER ALL BELOW LAVATORY TRIM WITH INSULATION KIT, LAVGARD BY TRUBRO.	1-1/4"	EXISTING			

1. DRAWINGS SHOW ONLY THE KNOWN SERVICES IN THE VICINITY OF THE PROJECT AREA.
2. CONTRACTOR SHALL VISIT THE PROJECT SITE AND FIELD VERIFY LOCATIONS, ELEVATIONS, AND SIZES OF ALL EXISTING SERVICES PRIOR TO STARTING CONSTRUCTION.
3. CONTRACTOR SHALL REMOVE, REWORK AND/OR REROUTE EXISTING SERVICES AS REQUIRED TO ACCOMPLISH THE WORK REQUIRED BY THIS CONTRACT.
4. CONTRACTOR SHALL COORDINATE THE DISRUPTION OF ANY SERVICE WITH THE LOCAL OWNER'S REPRESENTATIVE A MINIMUM OF 72 HOURS PRIOR TO SAID DISRUPTION TO MINIMIZE ANY INCONVENIENCE TO THE OWNER/USER.
5. EXISTING SERVICES, EQUIPMENT, AND FIXTURES TO REMAIN OR TO BE RELOCATED SHALL BE REPAIRED TO ORIGINAL OPERATION OR REPLACED SHOULD THEY BE DAMAGED DURING CONSTRUCTION.
6. ALL EXISTING WORK NOT SHOWN ON THESE DRAWINGS SHALL REMAIN AS IS UNLESS NOTED OTHERWISE.
7. CONTRACTOR SHALL COORDINATE EQUIPMENT CONNECTIONS WITH EQUIPMENT DRAWINGS AND SUPPLIER. CONTRACTOR SHALL INSTALL EQUIPMENT AND MAKE FINAL CONNECTIONS FURNISHING CUTOFF VALVES, P-TRAPS, PRESSURE REDUCING VALVES, AND PIPING AS REQUIRED.
8. CONTRACTOR SHALL COORDINATE WITH ALL DISCIPLINES INVOLVED TO AVOID ANY PIPE ROUTING PROBLEMS. IN THE EVENT CONFLICTS ARE ENCOUNTERED WHICH CANNOT BE RESOLVED BY THE TRADES INVOLVED, THE ARCHITECT SHALL BE CONSULTED AND HIS DECISION SHALL GOVERN.
9. ALL FIXTURES, EQUIPMENT AND PIPING SHOWN ON THESE DRAWINGS SHALL BE INSTALLED IN ACCORDANCE WITH ALL APPLICABLE FEDERAL, STATE AND LOCAL CODE REQUIREMENTS.



© ALLEN & HOSHALL
This document is proprietary and shall not be reproduced or used by others without prior written consent. These drawings are intended to be plotted in color. Contractor assumes all risk in utilizing these drawings in any other manner.



42 JACKSON STATE DRIVE,
JACKSON, TN 38301

No.	Revision Description	Date
-----	----------------------	------

JOB NO: 63745 DRAWN: TGS
DATE: 07.15.26 CONSTRUCTION DOCUMENTS

P0.1



© ALLEN & HOSHALL
This document is proprietary and shall not be reproduced or used by others without prior written consent. These drawings are intended to be plotted in color. Contractor assumes all risk in utilizing these drawings in any other manner.



42 JACKSON STATE DRIVE,
JACKSON, TN 38301


JOB NO: 63745 DRAWN: TGS
DATE: 07.15.26 CONSTRUCTION DOCUMENTS

LEGEND	
	SURFACE, WALL OR PENDENT MTD. LIGHTING FIXTURE
	RECESSED LIGHTING FIXTURE
	FIRE ALARM NOTIFICATION DEVICE - CEILING MOUNTED HORN AND STROBE
A	DENOTES FIXTURE TYPE A - SEE FIXTURE SCHEDULE
\$	SPST SWITCH WITH STAINLESS STEEL COVER PLATE - MTD. 48" AFF, UOI
	JUNCTION BOX
MTD	MOUNTED

GENERAL PROVISIONS, ELECTRICAL	
CONTRACTOR'S RESPONSIBILITY	
1.	CONTRACTOR AGREES TO ASSUME RESPONSIBILITY FOR LIABILITY, WORKMANSHIP, AND QUALITY OF MATERIALS CONCERNING WORK SUBLET TO OTHERS. ALL WORK SHALL BE INSTALLED UNDER THE CONSTANT SUPERVISION OF A QUALIFIED SUPERINTENDENT AND BY SKILLED AND QUALIFIED ELECTRICIANS.
2.	DRAWINGS ARE GENERALLY ORGANIZED BY DISCIPLINE FOR CONVENIENCE. CONTRACTOR IS RESPONSIBLE FOR ALL ELECTRICAL DEVICES, EQUIPMENT, LABOR, ECT SHOWN WITHIN THE CONTRACT DOCUMENTS.
CODES AND FEES	
3.	ALL WORK SHALL BE INSTALLED IN ACCORDANCE WITH THE APPLICABLE PROVISIONS OF THE LOCAL CODES, THE NATIONAL ELECTRICAL CODE, AND THE NATIONAL ELECTRICAL SAFETY CODE.
4.	ALL ELECTRICAL MATERIALS SHALL HAVE UNDERWRITERS' APPROVAL WHERE APPLICABLE, AND SHALL BE SO LABELED WHERE UL LABELING IS CUSTOMARY.
5.	ALL ELECTRICAL EQUIPMENT SHALL CONFORM TO APPLICABLE NEMA STANDARDS WHETHER SPECIFIED HEREINAFTER OR NOT, AND TO OTHER APPLICABLE STANDARDS WHICH MAY BE SPECIFIED HEREINAFTER.
6.	THE CONTRACTOR SHALL BE RESPONSIBLE FOR OBTAINING LOCAL PERMITS, PAYMENT OF FEES AND NOTIFICATION FOR INSPECTION BY CODE AUTHORITIES CONSISTENT WITH THE SCHEDULE OF WORK.
ACCURACY OF DATA AND DRAWINGS	
7.	DRAWINGS AND DATA: ELECTRICAL DRAWINGS ARE GENERALLY DIAGRAMMATIC, AND WHERE NOT DIMENSIONED OR DETAILED, INDICATE APPROXIMATE LOCATIONS AND GENERAL ARRANGEMENTS OF ELECTRICAL WORK. ALL ELECTRICAL WORK OFSETS, RISES, AND FITTINGS ARE NOT NECESSARILY SHOWN; HOWEVER, PROVIDE THESE AS REQUIRED BY THE CONDITIONS INVOLVED.
8.	BUILDING AND STRUCTURE DIMENSIONS: TAKE THESE FROM ARCHITECTURAL AND STRUCTURAL DRAWINGS AND FROM ACTUAL MEASUREMENTS MADE BY ELECTRICAL SECTION OF EACH EXISTING BUILDING AND EACH EXISTING STRUCTURE INVOLVED.
9.	EQUIPMENT NOT FURNISHED BY ELECTRICAL SECTION BUT REQUIRING ELECTRICAL CONNECTIONS: FROM OTHER SECTIONS AND OTHERS FURNISHING THIS EQUIPMENT, DETERMINE EXACT ELECTRICAL CONNECTION REQUIREMENTS THEREFORE; LOCATIONS AND ARRANGEMENTS OF ELECTRICAL CONNECTIONS INDICATED FOR THIS EQUIPMENT ARE APPROXIMATE ONLY.
EQUIPMENT LISTS, SHOP DRAWINGS, SAMPLES AND SUBMITTALS	
10.	SUBMIT UNDER PROVISIONS OF GENERAL CONDITIONS AND ADMINISTRATIVE REQUIREMENTS AS DEFINED BY FRONT END SPECIFICATIONS PROVIDED BY ARCHITECT.
11.	SUBMISSION MATERIAL AND ALL SHOP DRAWINGS FOR THE VARIOUS ITEMS OF EQUIPMENT SHALL BE MARKED WITH THE RESPECTIVE MARK NUMBER OR IDENTIFICATION OF THE EQUIPMENT SHOWN ON THE DRAWINGS OR SPECIFIED. THE SHOP DRAWINGS SHALL LIST ALL RATINGS, CAPACITIES, ACCESSORIES, AND OTHER PERTINENT DATA TO SHOW THAT THE PROPOSED ITEM IS AS CALLED FOR AND AS SPECIFIED.
QUALITY CONTROL	
12.	COMPLY WITH SECTION 00700 GENERAL CONDITIONS.
13.	QUALIFICATIONS: WHERE SPECIFIC QUALIFICATIONS ARE SPECIFIED IN INDIVIDUAL SPECIFICATION SECTION, PROVIDE REQUIRED DATA WITH SUBCONTRACTOR LIST.
GUARANTEE	
14.	COMPLY WITH REQUIREMENTS OF ARCHITECT'S GENERAL CONDITIONS. AT A MINIMUM GUARANTEE ALL MATERIALS AND WORKMANSHIP FOR ONE YEAR FROM DATE OF SUBSTANTIAL COMPLETION.
EQUIPMENT INSTALLATION	
15.	INSTALL ALL EQUIPMENT IN ACCORDANCE WITH APPLICABLE MANUFACTURER'S DRAWINGS AND RECOMMENDATIONS.
16.	IDENTIFICATION OF CIRCUITS AND EQUIPMENT: IDENTIFICATION DESIGNATIONS SHALL CORRESPOND TO THOSE INDICATED ON ELECTRICAL DRAWINGS AND AS SPECIFIED IN CORRESPONDING ARTICLES DESCRIBING THE EQUIPMENT.
ALTERATIONS AND ADDITIONS TO EXISTING ELECTRICAL WORK	
17.	MAKE ALTERATIONS AND ADDITIONS TO EXISTING ELECTRICAL WORK AS INDICATED, AND AS REQUIRED TO ACCOMMODATE NEW CONSTRUCTION AND TO CLEAR ALL INTERFERENCES THEREWITH. THIS INCLUDES DISCONNECTING, REMOVING, RELOCATING, REROUTING, EXTENDING, REWORKING, RECONNECTING, OR OTHERWISE ALTERING EXISTING ELECTRICAL WORK AS REQUIRED, WHETHER INDICATED ON THE DRAWINGS OR NOT.
18.	REMOVE ALL ACCESSIBLE EXISTING ABOVE GROUND CONDUITS AND ALL OTHER ACCESSIBLE EXISTING ELECTRICAL ITEMS WHICH ARE NOT REQUIRED FOR OPERATION OF THE COMPLETED PROJECT; AND REMOVE ALL CONDUCTORS FORM INACCESSIBLE EXISTING CONDUITS WHICH ARE NOT REQUIRED FOR OPERATION OF THE COMPLETED PROJECT; ALL UNLESS OTHERWISE INDICATED OR OTHERWISE APPROVED.
CONTINUITY OF EXISTING ELECTRICAL SERVICE, AND SALVAGED EXISTING ELECTRICAL MATERIALS	
19.	ARRANGE ALL ELECTRICAL WORK TO INTERFERE AS LITTLE AS POSSIBLE WITH OWNER'S NORMAL OPERATIONS. DO NOT INTERRUPT EXISTING ELECTRICAL SERVICE AT ANY TIME WITHOUT OWNER'S PRIOR APPROVAL. AFTER AN ELECTRICAL SERVICE INTERRUPTION HAS BEEN MADE, MAKE ALL NECESSARY CONNECTIONS AND ALTERATIONS, AND RESTORE ELECTRICAL SERVICE AS QUICKLY AS POSSIBLE. AT NO EXTRA COST TO OWNER, PROVIDE TEMPORARY ELECTRICAL CONNECTIONS AND OTHER ELECTRICAL WORK AS REQUIRED TO MAINTAIN CONTINUITY OF ELECTRICAL SERVICE.
20.	PROMPTLY HAUL AWAY FROM OWNER'S PREMISES ALL ELECTRICAL MATERIALS AND ELECTRICAL EQUIPMENT WHICH ARE REMOVED FROM EXISTING ELECTRICAL SYSTEM AND ARE NEITHER INDICATED NOT REQUIRED TO BE REUSED IN THE COMPLETED PROJECT, EXCEPT AS OTHERWISE SPECIFIED BELOW. OWNER MAY SELECT CERTAIN REMOVED EXISTING ELECTRICAL MATERIALS AND ELECTRICAL EQUIPMENT AND RETAIN THEM FOR HIS FUTURE USE. BEFORE REMOVING ANY EXISTING ELECTRICAL MATERIALS AND ELECTRICAL EQUIPMENT, DETERMINE FROM OWNER WHICH OF THESE MATERIALS AND EQUIPMENT (IF ANY) HE DESIRES TO RETAIN. REMOVE ALL OWNER-SELECTED ELECTRICAL MATERIALS AND ELECTRICAL EQUIPMENT WITHOUT UNNECESSARY DAMAGE THERETO, AND SAFELY STORE THEM AT LOCATIONS DESIGNATED BY OWNER.
TEMPORARY LIGHTS AND POWER	
21.	PROVIDE TEMPORARY LIGHTS AND POWER. LIGHTS SHALL BE ONE PISTAIL SOCKET AND 150W LAMP OR EQUIVALENT FOR EACH 500 SF BUILDING SPACE. MINIMUM ONE PER ROOM. POWER OUTLETS SHALL BE PROVIDED AS COORDINATED WITH CONSTRUCTION. EXISTING LIGHTING MAY BE USED AS TEMPORARY LIGHTING EXCEPT WHERE FIXTURES ARE INDICATED ON PLANS TO BE REINSTALLED.
TEST, INSPECTIONS, ADJUSTMENTS, AND CLEANUP	
22.	MAKE INSULATION TESTS WITH A "MEGGER", DEMONSTRATE THAT NEITHER SHORT CIRCUITS NOR GROUND FAULTS EXIST, AND THAT INSULATING COMES WITH NEC.
23.	FURNISH SUITABLE TESTING EQUIPMENT, GIVE THE ENGINEER AND ALL APPLICABLE AUTHORITIES AMPLE ADVANCE NOTICE OF ALL PROPOSED TESTS AND READINESS OF WORK FOR INSPECTIONS, AND CONDUCT EACH TEST IN THEIR PRESENCE, AS APPROVED. DO NOT CONCEAL ELECTRICAL WORK UNTIL ALL NECESSARY INSPECTIONS HAVE BEEN MADE AND ALL REQUIRED TESTS HAVE BEEN APPROVED BY THE OWNER'S REPRESENTATIVE AND ALL APPLICABLE AUTHORITIES.
24.	PUT ENTIRE ELECTRICAL SYSTEM IN OPERATION, TEST ALL EQUIPMENT, REMEDY ALL DEFECTS, AND MAKE ALL NECESSARY ADJUSTMENTS. DEMONSTRATE THAT THE ENTIRE SYSTEM FUNCTIONS SATISFACTORILY, AS SPECIFIED, AS INDICATED, AND AS APPROVED.
25.	AFTER ELECTRICAL SYSTEM HAS BEEN TESTED AND BEFORE ANY FIELD PAINTING IS COMMENCED, CLEAN UP ALL ELECTRICAL WORK THOROUGHLY. REMOVE ALL FOREIGN MATTER WHICH HAS ACCUMULATED IN ALL FIXTURES, EQUIPMENT, AND ENCLOSURES, CLEAN ALL FIXTURE GLASSWARE AND REFLECTORS, AND CLEAN AND POLISH ALL OTHER SURFACES THAT ARE NOT TO BE PAINTED SO THAT THEY PRESENT A NEW AND ACCEPTABLE APPEARANCE.
26.	CONTRACTOR SHALL TEST EACH RECEPTABLES PER NFPA TO VERIFY PHYSICAL INTEGRITY, THE CONTINUITY OF THE GROUNDING CIRCUIT AND CORRECT POLARITY AND PROPER RETENTION FORCE OF THE GROUNDING BLADE. PROVIDE DOCUMENTATION TO OWNER IN A TYPE-WRITTEN TABLE WHICH INCLUDES DATE, ROOM NAME/NUMBER AND LOCATION IN ROOM WITH INDICATION THAT RECEPTABLE HAS MET THE PERFORMANCE REQUIREMENTS OF NFPA.
27.	CONTRACTOR SHALL ENSURE ARC FLASH HAZARD ANALYSIS IS PERFORMED FOR ALL 480V (OR HIGHER) ELECTRICAL EQUIPMENT ADDED OR MODIFIED WITHIN PROJECT SCOPE. CONTRACTOR SHALL ALSO ENSURE LABELING IS AFFIXED TO THIS EQUIPMENT DISPLAYING THE RESULTING PERTINENT ARC FLASH INFORMATION - COORDINATE WITH OWNER FOR REQUIREMENTS OF ANALYSIS AND LABELING.
PROTECTION AND CLEANING	
28.	WORK SHALL BE PROTECTED AT ALL TIMES. CONDUIT OPENINGS SHALL BE CLOSED WITH CAPS OR PLUGS UNTIL PERMANENT CONNECTIONS ARE MADE. FIXTURES AND EQUIPMENT SHALL BE COVERED, IF NECESSARY, TO PROTECT AGAINST DIRT, WATER, CHEMICAL OR MECHANICAL DAMAGE OR DEFACEMENT. THE INSTALLATION OF FIXTURES LIABLE TO DAMAGE SHALL BE COORDINATED WITH INSTALLING UL FIRE PROTECTIVE BARRIERS AND CEILING SYSTEMS.
29.	ELECTRICAL EQUIPMENT ROOMS SHALL BE CLEANED UP PRIOR TO ENERGIZING EQUIPMENT AND SHALL NOT BE USED FOR STORAGE OR OTHER PURPOSES AFTER POWER IS APPLIED TO THE ELECTRICAL EQUIPMENTS.
OPERATING INSTRUCTIONS	
30.	FURNISH THE SERVICES OF A COMPETENT MAN (OR MEN) TO INSTRUCT THE OWNER'S PERSONNEL IN THE PROPER OPERATION AND MAINTENANCE OF ALL EQUIPMENT, FOR A PERIOD OF NOT LESS THAN FIVE WORKING DAYS.
31.	FURNISH AND DELIVER TO THE OWNER THREE SETS OF OPERATING INSTRUCTIONS FOR ALL EQUIPMENT INSTALLED UNDER THIS CONTRACT, INCLUDING SHOP DRAWINGS, PIPING DIAGRAMS, WIRING DIAGRAMS, MAINTENANCE RECOMMENDATIONS AND INFORMATION CONCERNING REPLACEMENT PARTS.

GENERAL AND DEMOLITION NOTES

1. ALL CIRCUITRY (WIRES, CONDUITS, CONTROLS, DISCONNECTS, ETC.) FOR MECHANICAL ITEMS BEING DEMOLISHED SHALL BE DEMOLISHED BACK TO THE PANEL FROM WHICH THEY ARE SERVED, UOI. SEE MECHANICAL DEMOLITION SHEETS FOR EXACT LOCATIONS AND COORDINATE WITH MECHANICAL/CONTROLS CONTRACTOR.
2. ALL LOW VOLTAGE WIRING NOT INSTALLED IN CONDUIT SHALL BE PLENUM RATED.
3. ELECTRICAL BOXES ON THE SAME OR OPPOSITE FACES OF THE SAME FIRE-RESISTANT WALL SHALL BE SEPARATED BY A HORIZONTAL DISTANCE OF 24 INCHES (MINIMUM). FOR INSTANCES IN WHICH THIS 24 INCH SEPARATION CANNOT BE MAINTAINED, CONTRACTOR SHALL PROVIDE FIRE RETARDANT WRAP FOR ELECTRICAL BOXES - ENSURE WALL FIRE RATING IS PROPERLY MAINTAINED.
4. ANY NON-FUSED DISCONNECT (REGARDLESS OF WHO PROVIDES IT) SHALL BE SERVED FROM A HACR RATED BREAKER IN THE PANEL IT IS FED FROM.
5. ANY DEMOLISHED, MODIFIED OR NEW CIRCUITS SHALL BE CLEARLY RECORDED AT THE PANEL WITH NEW, TYPED DIRECTORIES. SPARE BREAKERS SHALL BE CLEARLY LABELED AS "SPARE". IN ADDITION, CONTRACTOR SHALL LABEL EACH NEW PIECE OF MECHANICAL EQUIPMENT WITH ITS CORRESPONDING CIRCUIT # AND PANEL LOCATION USING A TYPE LABEL (LOCATED WHERE EASILY VISIBLE).
6. CONTRACTOR SHALL VERIFY THAT ALL NEW MECHANICAL EQUIPMENT INSTALLED HAS A SERVICE RECEPTACLE LOCATED WITHIN 25' OF IT. IF A SERVICE RECEPTACLE DOES NOT EXIST WITHIN 25', CONTRACTOR SHALL PROVIDE A SERVICE RECEPTACLE FOR ALL NEW MECHANICAL EQUIPMENT AS REQUIRED BY ALL APPLICABLE CODES AND CONTRACT SPECIFICATIONS. REQUIREMENTS SHALL BE UNDERSTOOD BY CONTRACTOR CONDUCTING SITE VISIT PRIOR TO BID.
7. CONTRACTOR SHALL INSTALL ALL CIRCUITS IN THE PANELBOARD IN A BALANCED MANNER, RESULTING IN BUS LOADS THAT ARE DISTRIBUTED AS EVEN AS POSSIBLE AND DO NOT EXCEED THE BUS AMP RATING.
8. CONTRACTOR SHALL ENSURE ALL EXISTING DUCT-MOUNTED SMOKE DETECTORS MAINTAIN PRE-CONSTRUCTION FUNCTIONALITY. EXISTING DUCT DETECTORS INTERLOCKED WITH EQUIPMENT BEING REPLACED SHALL BE INTERLOCKED WITH THE NEW EQUIPMENT AND PROVIDE SIMILAR EQUIPMENT SHUTDOWN. PROVIDE ALL ADDITIONAL APPURTENANCES AS REQUIRED FOR FULLY FUNCTIONAL SYSTEM PER ALL APPLICABLE CODES.
9. CONTRACTOR SHALL PROPERLY SEAL ALL NEW FIRE WALL PENETRATIONS AS REQUIRED PER ALL APPLICABLE CODES.
10. ALL REQUIRED DOCUMENTATION REGARDING THE DESIGN OF FIRE DETECTION, ALARM, AND COMMUNICATIONS SYSTEMS AND THE PROCEDURES FOR MAINTENANCE, INSPECTION, AND TESTING OF FIRE DETECTION, ALARM, AND COMMUNICATIONS SYSTEMS SHALL BE MAINTAINED AT AN APPROVED, SECURED LOCATION FOR THE LIFE OF THE SYSTEM.
11. THE FIRE ALARM CONTROL PANEL CIRCUIT DISCONNECTING MEANS SHALL HAVE A RED MARKING, SHALL BE ACCESSIBLE ONLY TO AUTHORIZED PERSONNEL, AND SHALL BE IDENTIFIED AS "FIRE ALARM CIRCUIT." THE LOCATION OF THE CIRCUIT DISCONNECTING MEANS SHALL BE PERMANENTLY IDENTIFIED AT THE FIRE ALARM CONTROL UNIT.
12. ALL ELECTRICAL SUBMITTALS SHALL BE ON LOCAL MANUFACTURER'S LETTERHEAD.

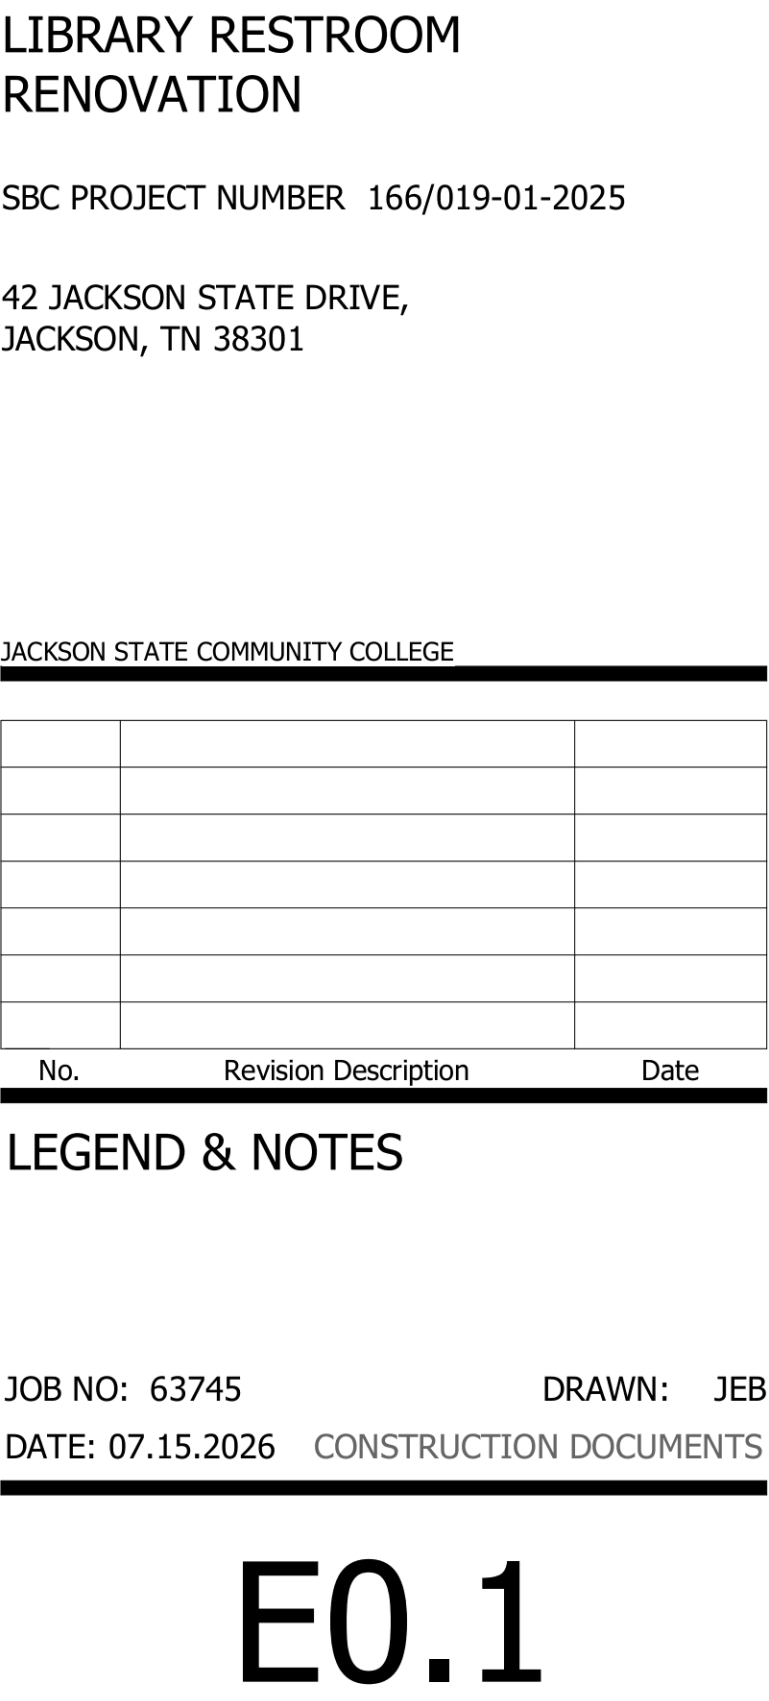

LIGHTING FIXTURE SCHEDULE									
TYPE MARK	MANUFACTURER	Model	DESCRIPTION	MOUNTING	Apparent Load	WATTAGE	VOLTAGE	LUMENS	Color Temperature
A	JUNO	RB56 SWW5 MW M6	WAFER FIXTURE IN EXISTING RECESSED CAN	RECESSED	11 VA	11 W	120 V	1000 LM	3500 K
B	JUNO	RB56 SWW5 CP6 MW M2	REMODEL RECESSED WAFER	RECESSED	11 VA	11 W	120 V	1000 LM	3500 K
C	MARK ARCHITECTURAL LIGHTING	SCT MIN10 FLL MVOLT WHTT2T PDT	SURFACE LINEAR - 4" WIDTH WITH INTGRAL OCCUPANCY SENSOR	SURFACE	70 VA	70 W	120 V	2400 LM	3500 K
D	LITHONIA LIGHTING	CLX L36 5,250 SEF 35K 80CRI	SURFACE MOUNTED STRIP LIGHT	SURFACE	40 VA	40 W	120 V	3750 LM	3500 K

SHEET NOTES
CONTRACTOR SHALL VERIFY EXISTING LOCATION AND MANUFACTURE OF FIRE ALARM SYSTEM AND COMPATIBILITY WITH NEW DEVICES


KEYNOTE LEGEND	
E1	DEMOLISH EXISTING LIGHT FIXTURES AND SURFACE MOUNTING JUNCTION BOX ABOVE DROP CEILING.
E2	DEMOLISH EXISTING LIGHT FIXTURES AND JUNCTION BOX. PREPARE CEILING FOR RECESSED CAN LIGHT.
E3	DEMOLISH SWITCH. KEEP JUNCTION BOX AND WIRING INTACT.
E4	DEMOLISH LIGHT FIXTURE. KEEP JUNCTION BOX AND WIRING INTACT.
E5	REUSES EXISTING LOCATION, WIRING AND JUNCTION BOXES. REPLACE LIGHT SWITCH AND FIXTURES.
E6	CONNECT TO EXISTING FIRE ALARM SYSTEM.




Allen&Hoshall
engineers • architects • surveyors

Allen & Hoshall
1661 International Drive, Suite 100
Memphis, TN 38120
901 820 0820 fax 866 270 6330

© ALLEN & HOSHALL
This document is proprietary and shall not be reproduced or used by others without prior written consent.
These drawings are intended to be plotted in color. Contractor assumes all risk in utilizing these drawings in any other manner.

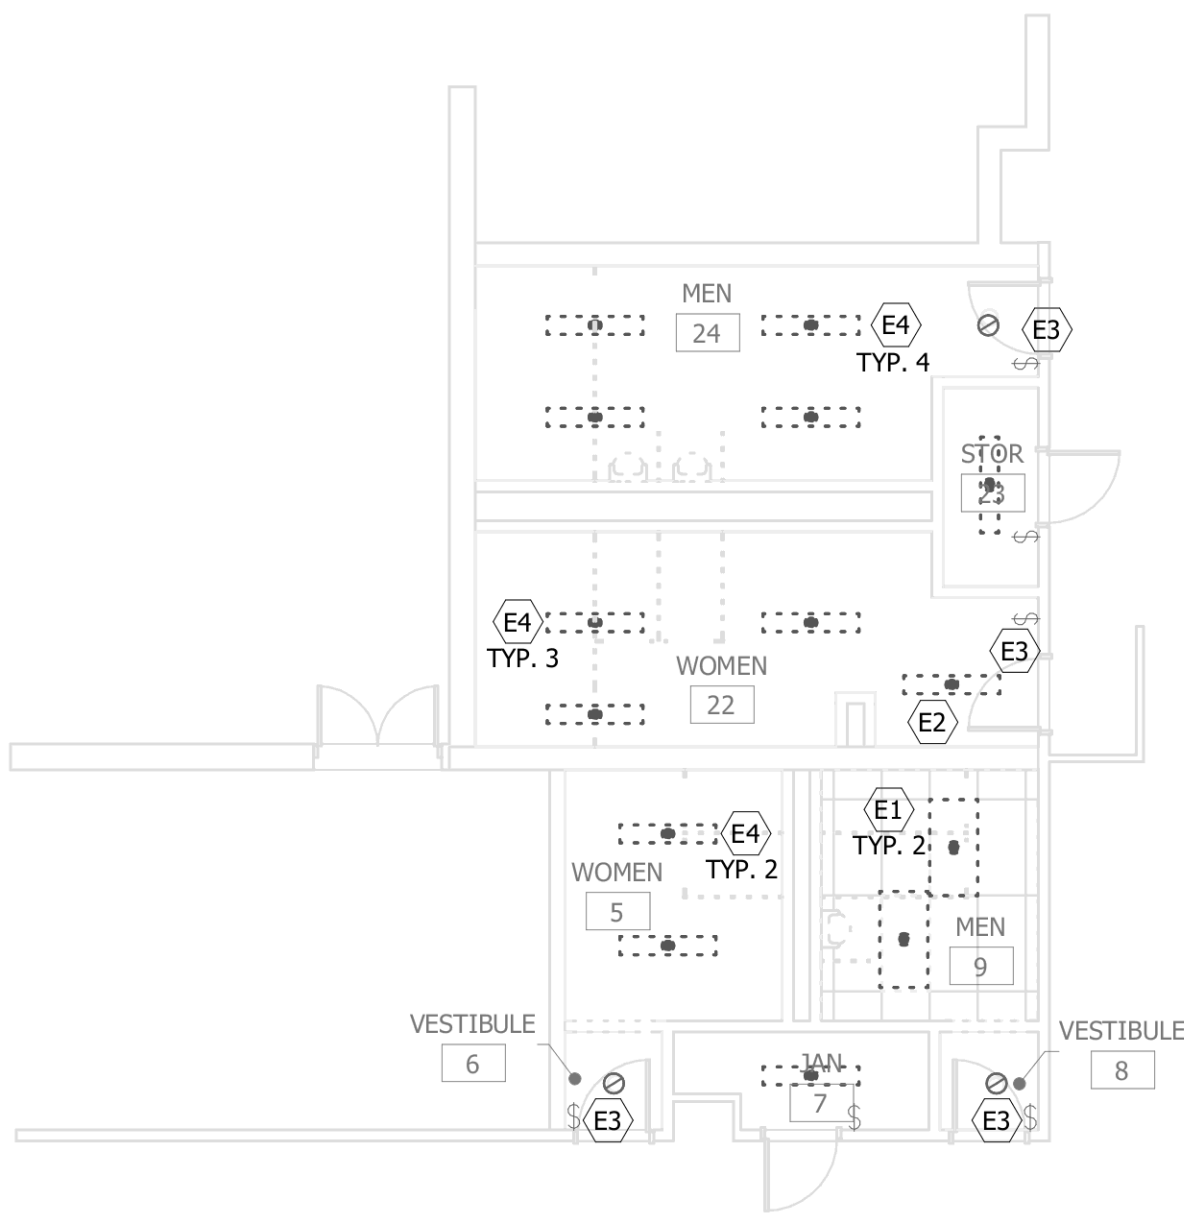

2 RCP LIGHTING DEMOLITION PLAN
1/8" = 1'-0"

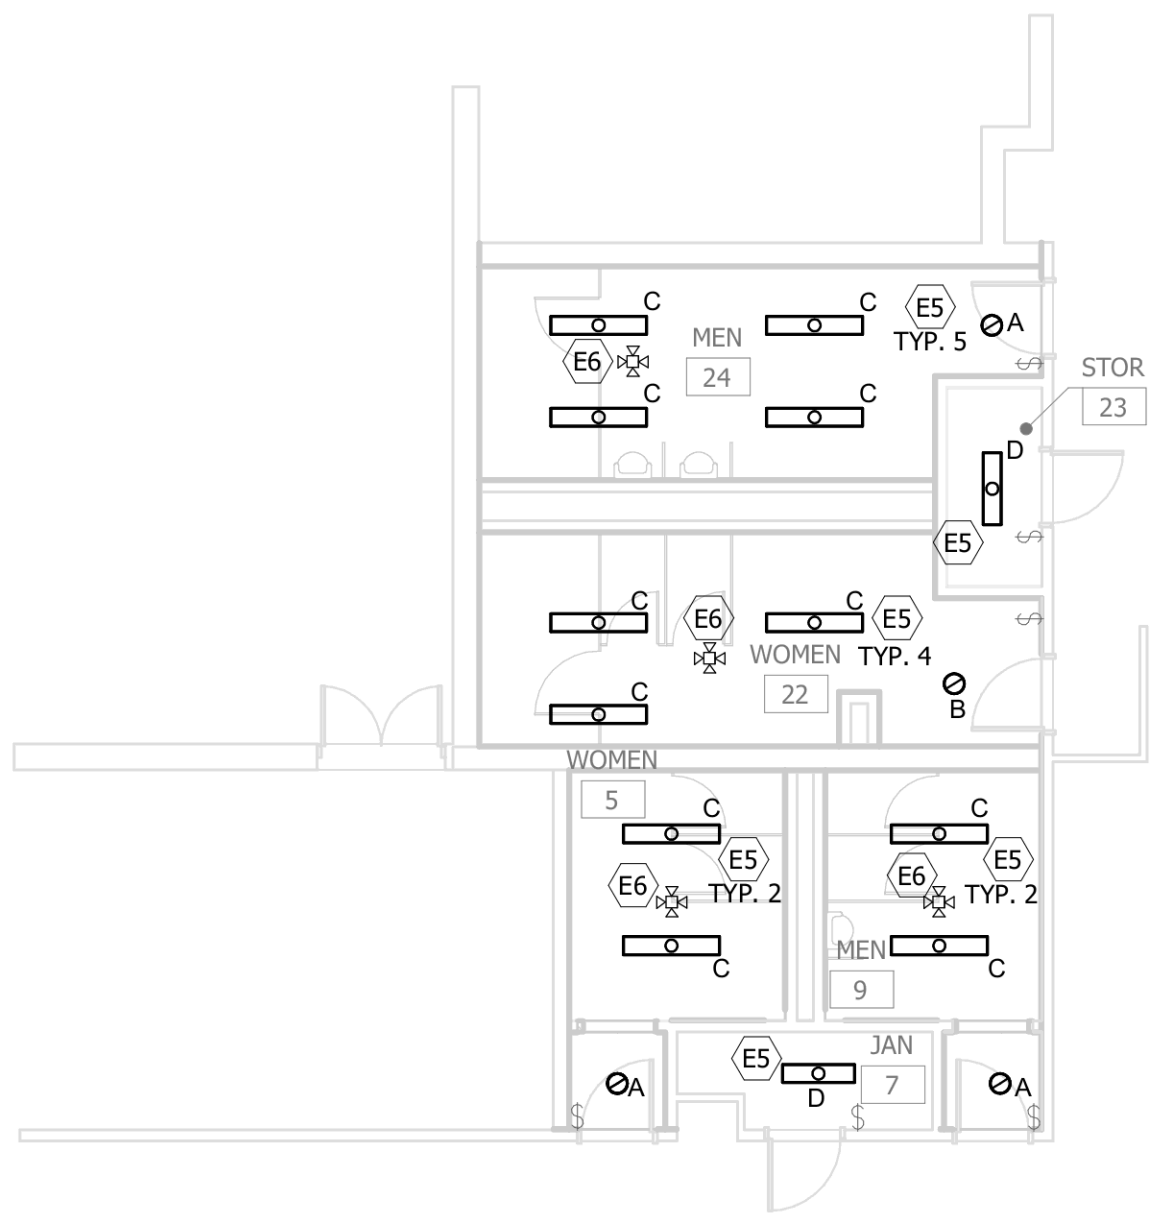

1 RCP LIGHTING PLAN
1/8" = 1'-0"

LIBRARY RESTROOM RENOVATION

SBC PROJECT NUMBER 166/019-01-2025

42 JACKSON STATE DRIVE,
JACKSON, TN 38301

JACKSON STATE COMMUNITY COLLEGE

No.	Revision Description	Date

DEMOLITION & NEW WORK - ELECTRICAL

JOB NO: 63745 DRAWN: JEB
DATE: 07.15.2026 CONSTRUCTION DOCUMENTS

E1.1